


FIRE ALARM UPGRADES LAKE COUNTY AREA VO-TECH

TAVARES, FLORIDA SCHOOL BOARD OF LAKE COUNTY

SCHOOL BOARD MEMBERS

KYLEEN FISHER, CHAIRMAN - DISTRICT 5
SCOTT STRONG - VICE CHAIRMAN - DISTRICT 2
DENNIS REID - DISTRICT 1
BECKY ELSWICK - DISTRICT 3
JIMMY CONNER, CHAIRMAN - DISTRICT 4

PAM SAYLOR, ESQ. - SUPERINTENDENT

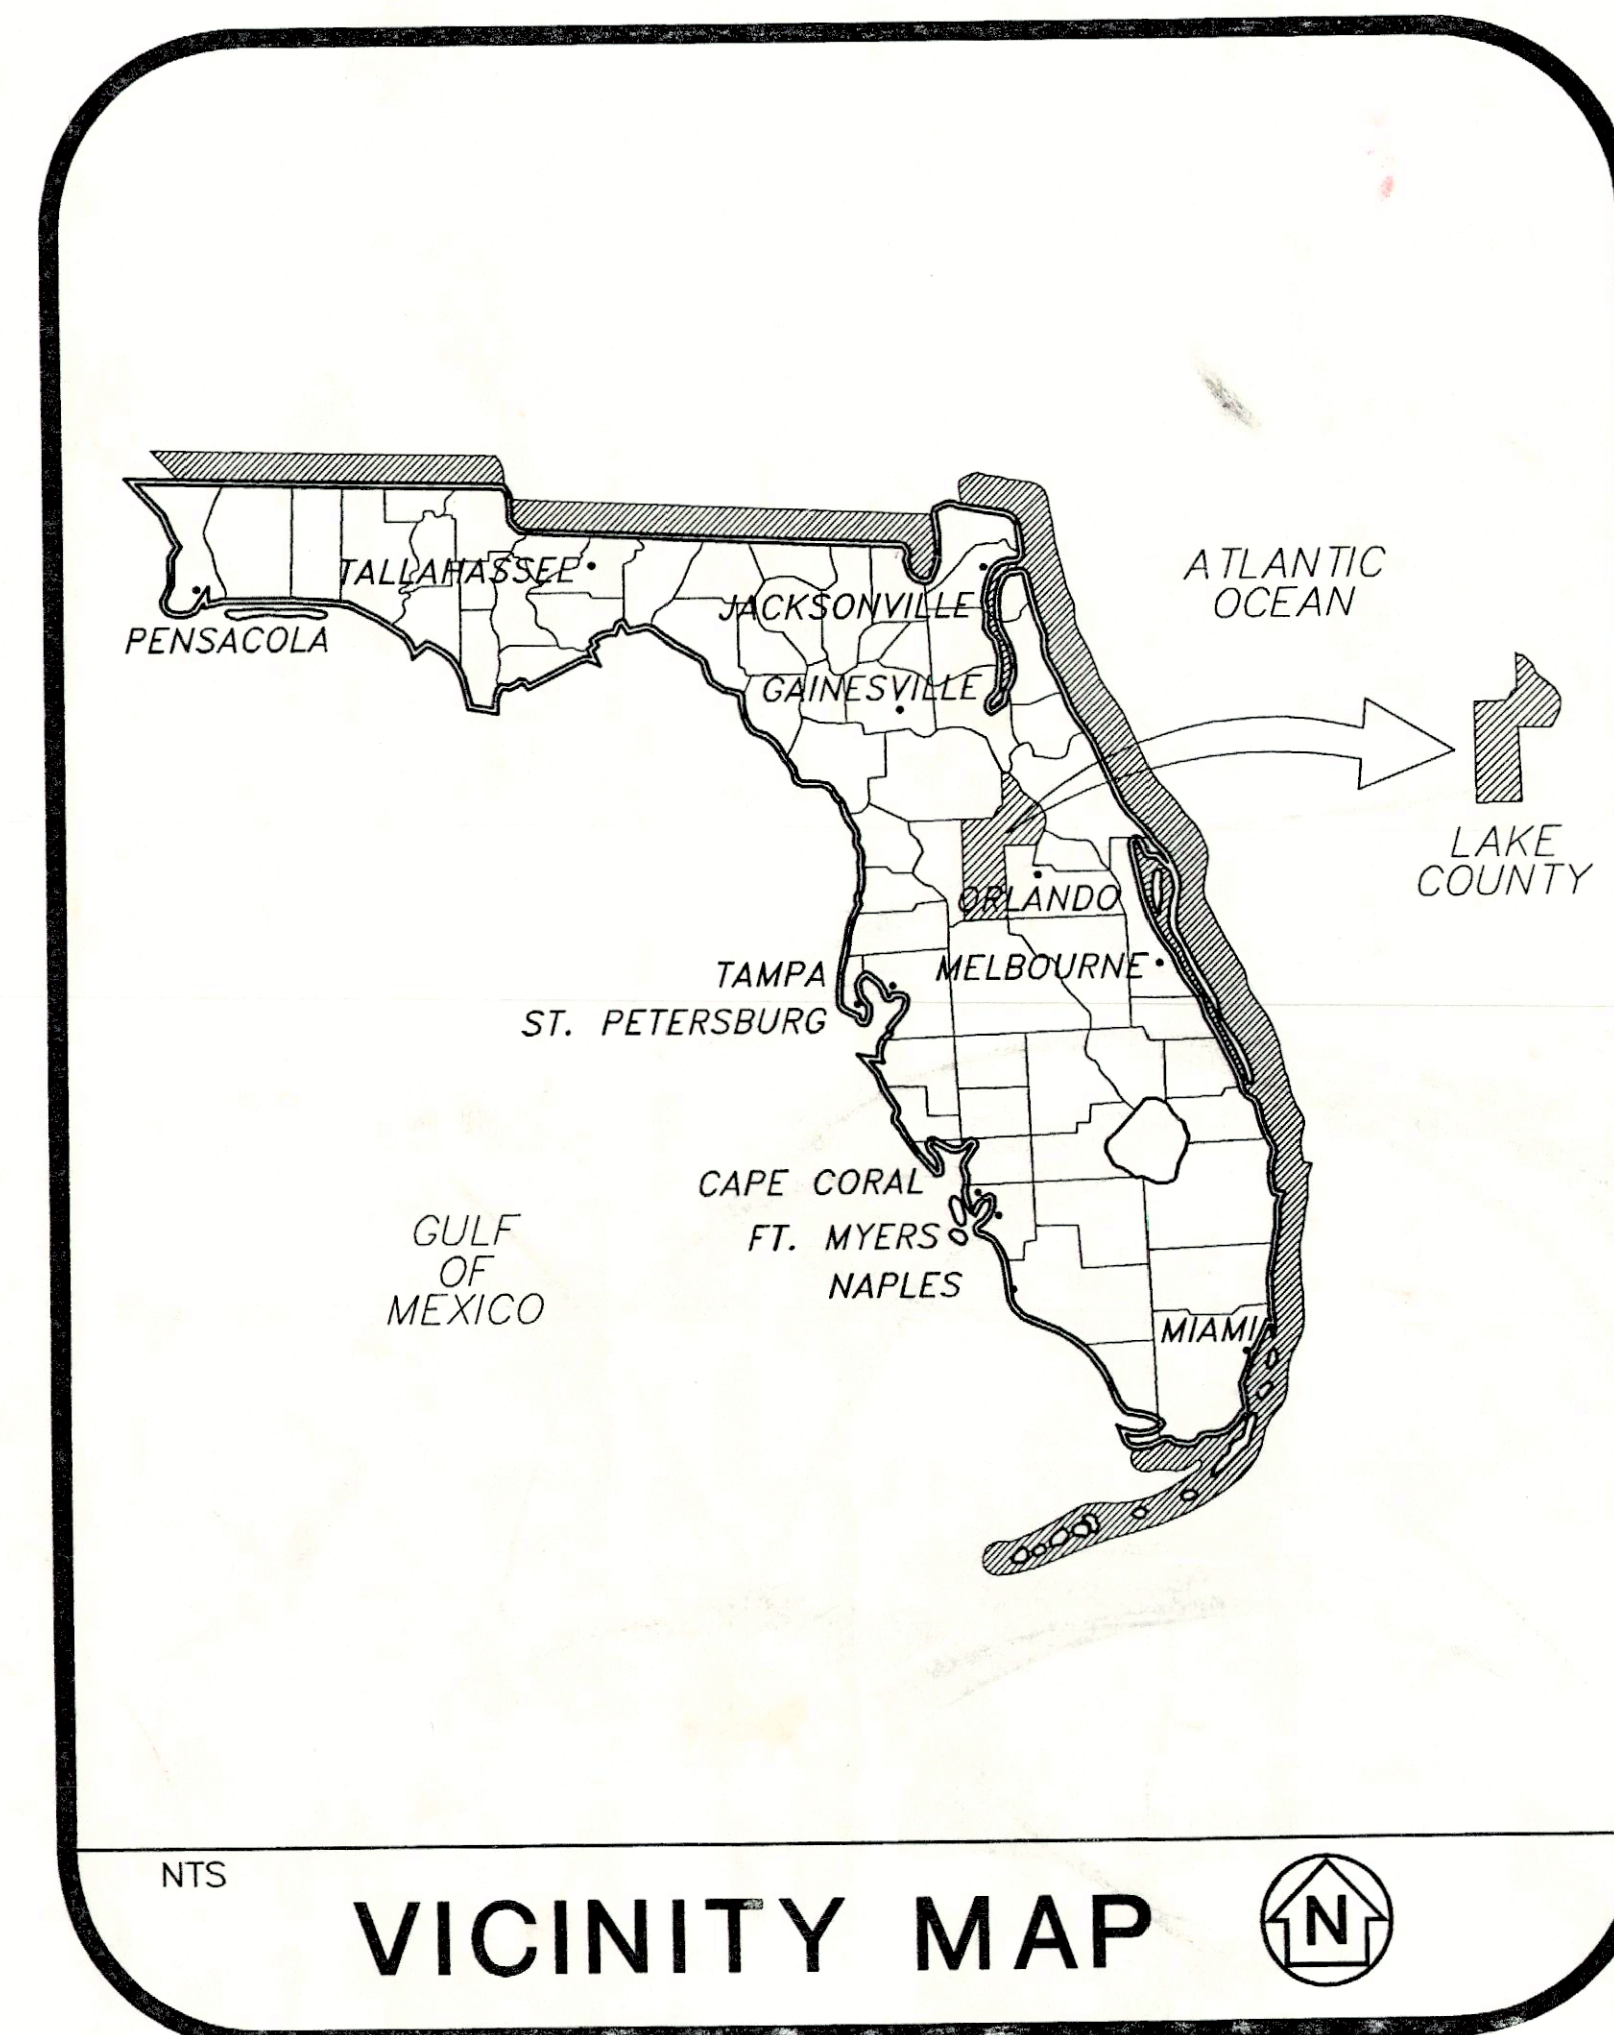

VICINITY MAP

DRAWING #	DRAWING TITLE	REV
EC-1	ELECTRICAL COVER SHEET	
E-1	SYMBOLS, NOTES & ABBREVIATIONS	
E-2	FIRE ALARM RISER & DIAGRAMS	
E-3	BLDG. 01A, 01B & 01C FIRE ALARM PLAN	
E-4	BLDG. 01D, 01E & 01F FIRE ALARM PLAN	
E-5	BLDG. 02A & 02C FIRE ALARM PLAN	
E-6	BLDG. 02B FIRE ALARM PLAN	
E-7	BLDG. 02D & 05 FIRE ALARM PLAN	
E-8	BLDG. 99 FIRE ALARM PLAN	
E-9	BLDG. 03 & 12 FIRE ALARM PLAN	
E-10	BLDG. 06 FIRE ALARM PLAN	

DRAWING INDEX

NOTE: TO THE BEST OF OUR KNOWLEDGE, THESE DRAWINGS AND THE PROJECT MANUAL ARE COMPLETE AND COMPLY WITH THE "STATE REQUIREMENTS FOR EDUCATIONAL FACILITIES, 1999".



BRPH IS A MEMBER OF THE AMERICA'S SCHOOLHOUSE COUNCIL.
A NATIONAL CONSORTIUM OF SCHOOL FACILITIES PROFESSIONALS
WORKING TO PROMOTE THE DEVELOPMENT OF QUALITY
EDUCATIONAL FACILITIES.
www.americasschoolhousecouncil.com

FIRE ALARM UPGRADES
LAKE COUNTY AREA VO-TECH
LAKE COUNTY SCHOOLS
ELECTRICAL COVER SHEET

BRPH ARCHITECTS ENGINEERS, INC.
MELBOURNE / ORLANDO / WEST PALM BEACH
3275 SUNTREE BOULEVARD
MELBOURNE, FLORIDA 32940
Board of Architecture License No. AA 000148
Board of Professional Engineers License No. 1433
Copyright © 2003
These plans are produced by Federal Copyright.
Unauthorized use may result in civil and criminal penalties.


DESIGNED BY
CARD
DRAWN BY
CARD
CHECKED BY
SNIDER
PROJECT NO./TAD CODE
5206\EC-1
DATE
12-22-03
DRAWING NO.
EC-1
SHEET
OF

(APPLIES TO ALL ELECTRICAL DRAWINGS.)

A	AMPERES	HID	HIGH INTENSITY DISCHARGE	O.C.	ON CENTER
AC	ALTERNATING CURRENT	HOA	HAND-OFF-AUTOMATIC SELECTOR SWITCH	OL	OVERLOAD
AFF	ABOVE FINISHED FLOOR	HP	HORSEPOWER	P	POLE
AFG	ABOVE FINISHED GRADE	HVAC	HEATING, VENTILATING & AIR CONDITIONING	PB	PUSHBUTTON STATION
AHU	AIR HANDLING UNIT	HZ	HERTZ	PC	PHOTOCELL
AM	AMMETER	IMC	INTERMEDIATE METAL CONDUIT	PNL	PANEL
AS	AMMETER SELECTOR	INC	INCANDESCENT	PVC	POLYVINYL CHLORIDE
ASY	ASYMMETRICAL	IG	ISOLATED GROUND	RM	ROOM
AWG	AMERICAN WIRE GAUGE	J	JUNCTION BOX	RCS	RIGID GALVANIZED STEEL
C	CONDUIT	KAIC	(THOUSAND) AMPERE INTERRUPTING	RECIP	RECEPTACLE
CB	CIRCUIT BREAKER	KVA	KILOVOLT-AMPERES	SN	SOLID NEUTRAL
CH	COUNTER HEIGHT	KW	KILOWATT	SPEC	SPECIFICATION
CKTS	CIRCUITS	LA	LIGHTNING ARRESTOR	SQ	SQUARE
CONC	CONCRETE	LC	LIGHTING CONTACTOR	SW	SWITCH
CTS	CURRENT TRANSFORMER	LED	LIGHT EMITTING DIODE	SWBD	SWITCHBOARD
DISC	DISCONNECT	LTG	LIGHTING	SYM	SYMMETRICAL
DN	DOWN	MAX	MAXIMUM	TEL	TELEPHONE
DWG	DRAWING	MECH	MECHANICAL	TS	TIMESWITCH
EDH	ELECTRIC DUCT HEATER	MH	METAL HALIDE	TB	TELEPHONE TERMINAL BOARD
EF	EXHAUST FAN	MIN	MINIMUM	TV	TELEVISION
ELEC	ELECTRICAL	N	NEUTRAL	TYP	TYPICAL
EM	EMERGENCY	NA	NOT APPLICABLE	UG	UNDERGROUND
EMT	ELECTRICAL METALLIC TUBING	NAC	NOTIFICATION APPLIANCE CIRCUIT	UL	UNDERWRITER'S LABORATORIES
EP	EXPLOSION PROOF	N.C.	NORMALLY CLOSED	UN	UNLESS OTHERWISE NOTED
EPO	ELECTRIC POWER OFF	NF	NON-FUSED	V	VOLTS
EUH	ELECTRIC UNIT HEATER	NEC	NATIONAL ELECTRICAL CODE	VA	VOLT AMPERES
EWC	ELECTRIC WATER COOLER	NEC	NOT IN CONTRACT	VM	VOLTMETER
EW	ELECTRIC WATER HEATER	NL	NIGHT LIGHT	VS	VOLTMETER SELECTOR
EXST	EXISTING	NO	NUMBER	W	WIRE
FACP	FIRE ALARM CONTROL PANEL	NEMA	NATIONAL ELECTRICAL MANUFACTURERS ASSOC.	WP	WEATHERPROOF
GFI	GROUND FAULT INTERRUPTER	NFPA	NATIONAL FIRE PROTECTION ASSOCIATION		
GND	GROUND	NTS	NOT TO SCALE		
GRC	GALVANIZED RIGID CONDUIT				
GW	GAS WATER HEATER				


SYMBOLS, NOTES & ABBREVIATIONS

ARCH/ENGR OF RECORD
DESIGNED BY CARD
DRAWN BY PRESSMAN
CHECKED BY
PROJECT NO./CAD CODE 5206.10/E01
DATE 12-22-03
DRAWING NO. E-1
SHEET OF

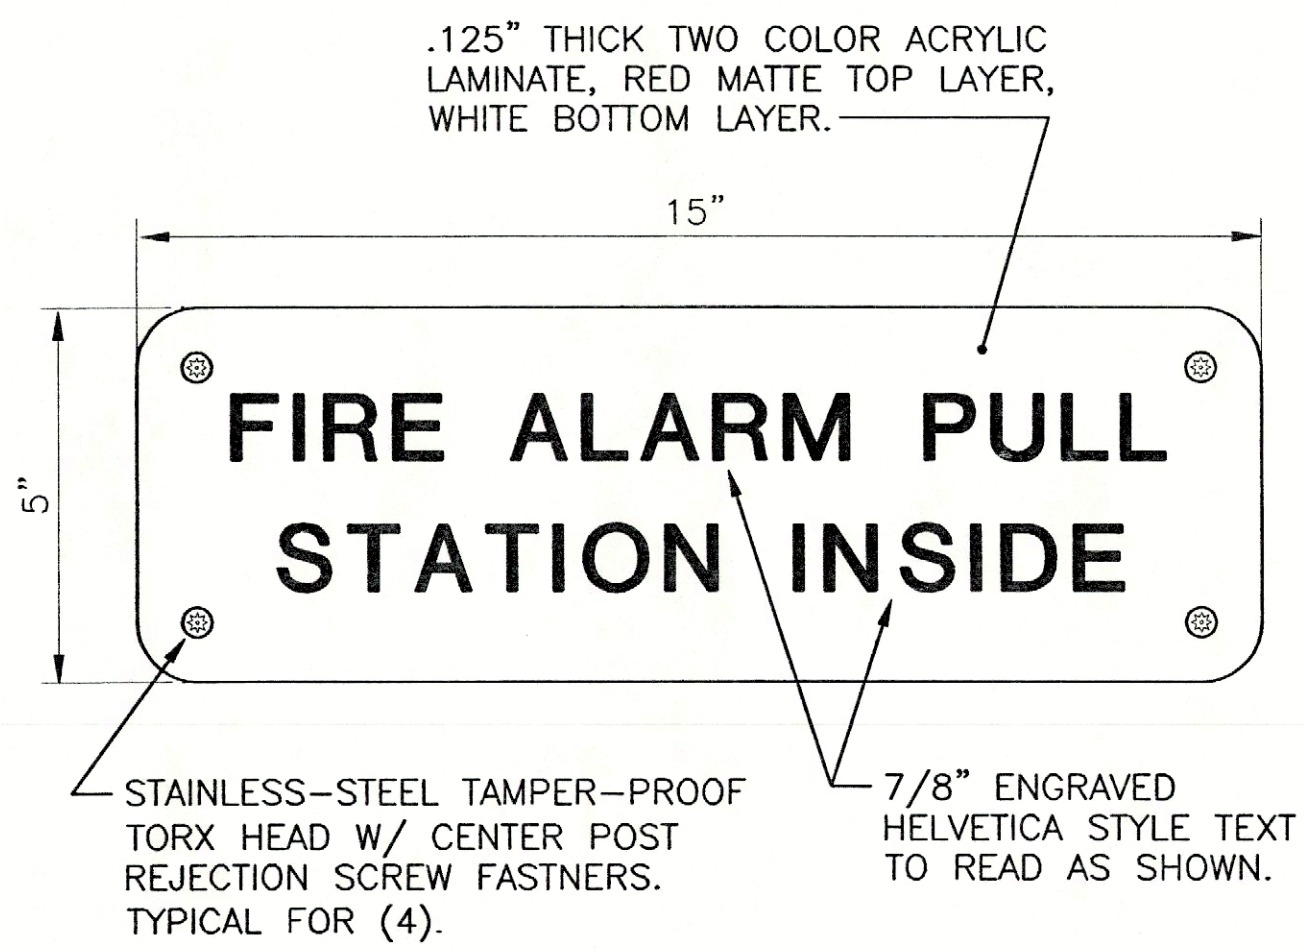


SIGNAGE - PULL STATION
N.T.S.

- NOTES:
1. ALL INTERIOR FIRE ALARM PULL STATIONS SHALL HAVE SIGNAGE AT THE NEAREST EXTERIOR DOOR.
 2. PROVIDE BRAILLE PICTOGRAM OF MESSAGE ON FIRE ALARM SIGNAGE AS REQUIRED PER DOE SPECIFICATIONS.

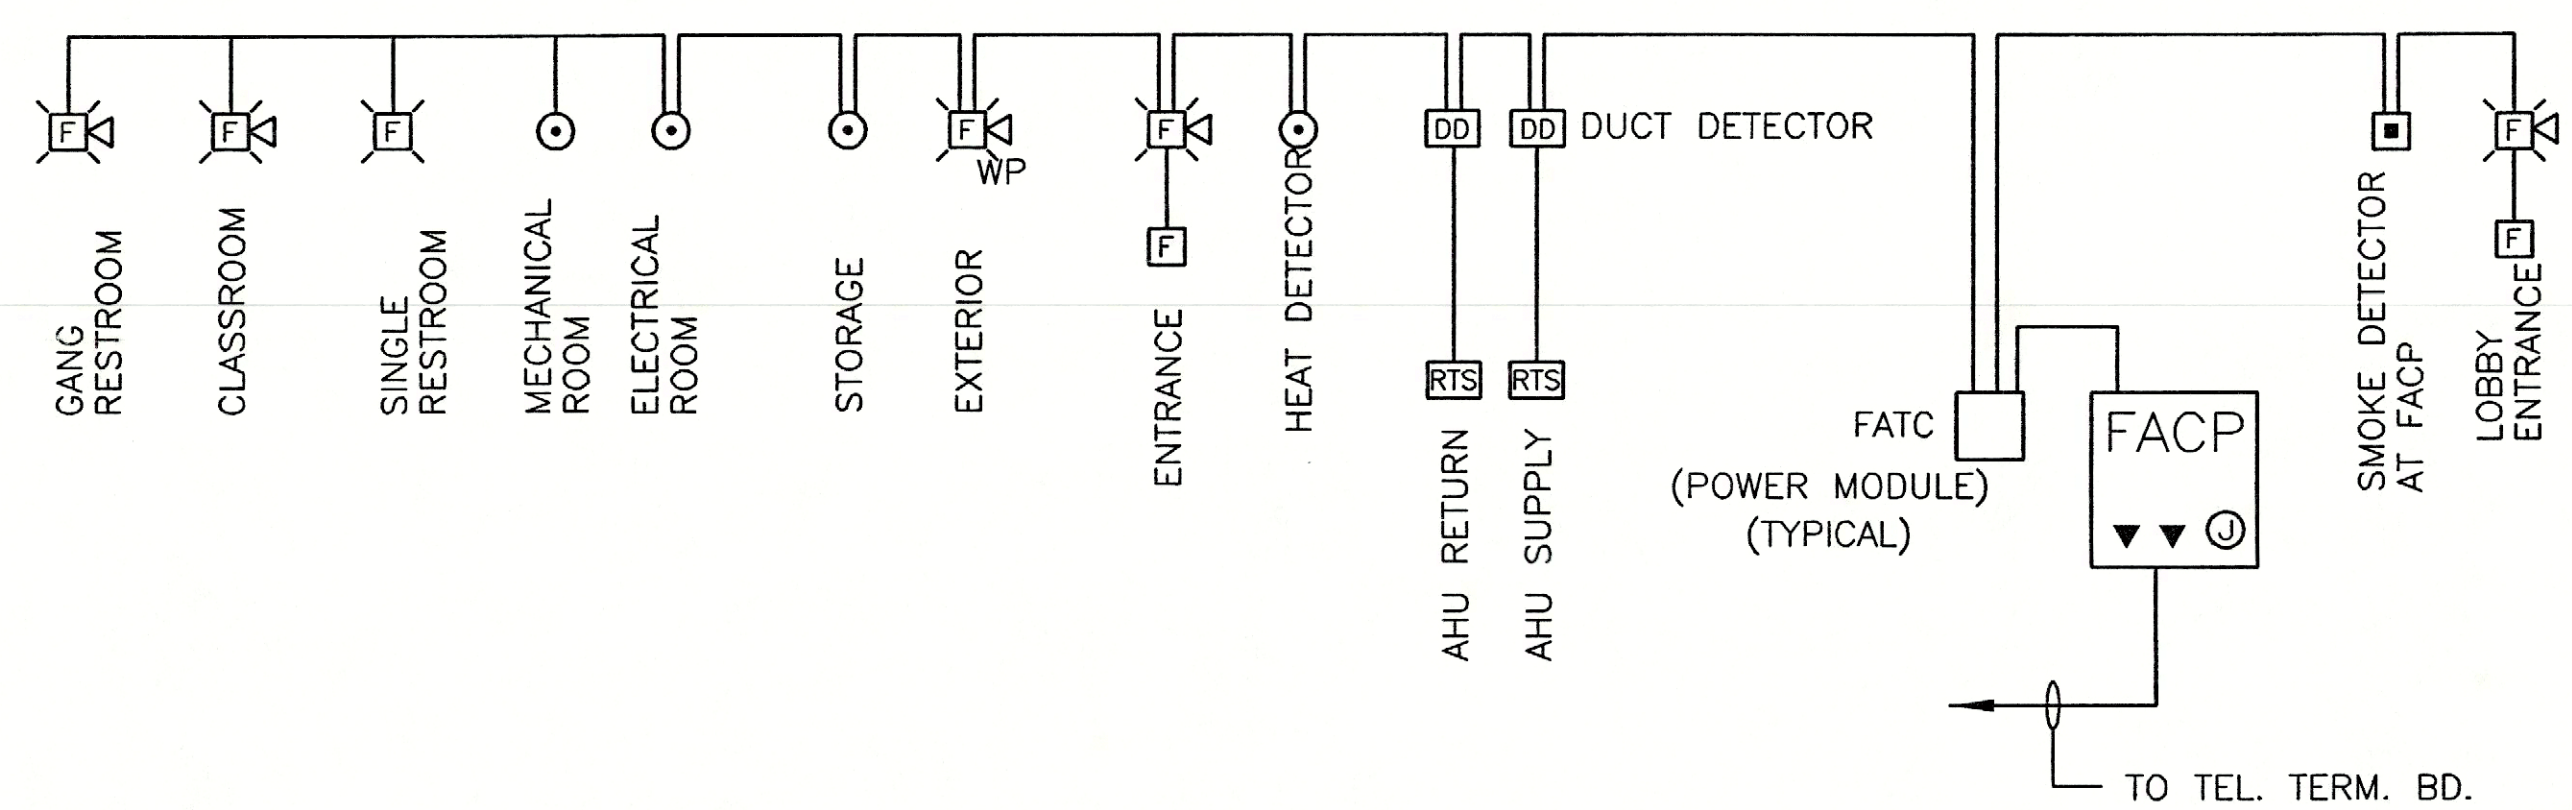

TYPICAL FIRE ALARM RISER DIAGRAM
NTS
CONTRACTOR SHALL REFER TO FLOOR PLANS FOR EXACT QUANTITY OF DEVICES.

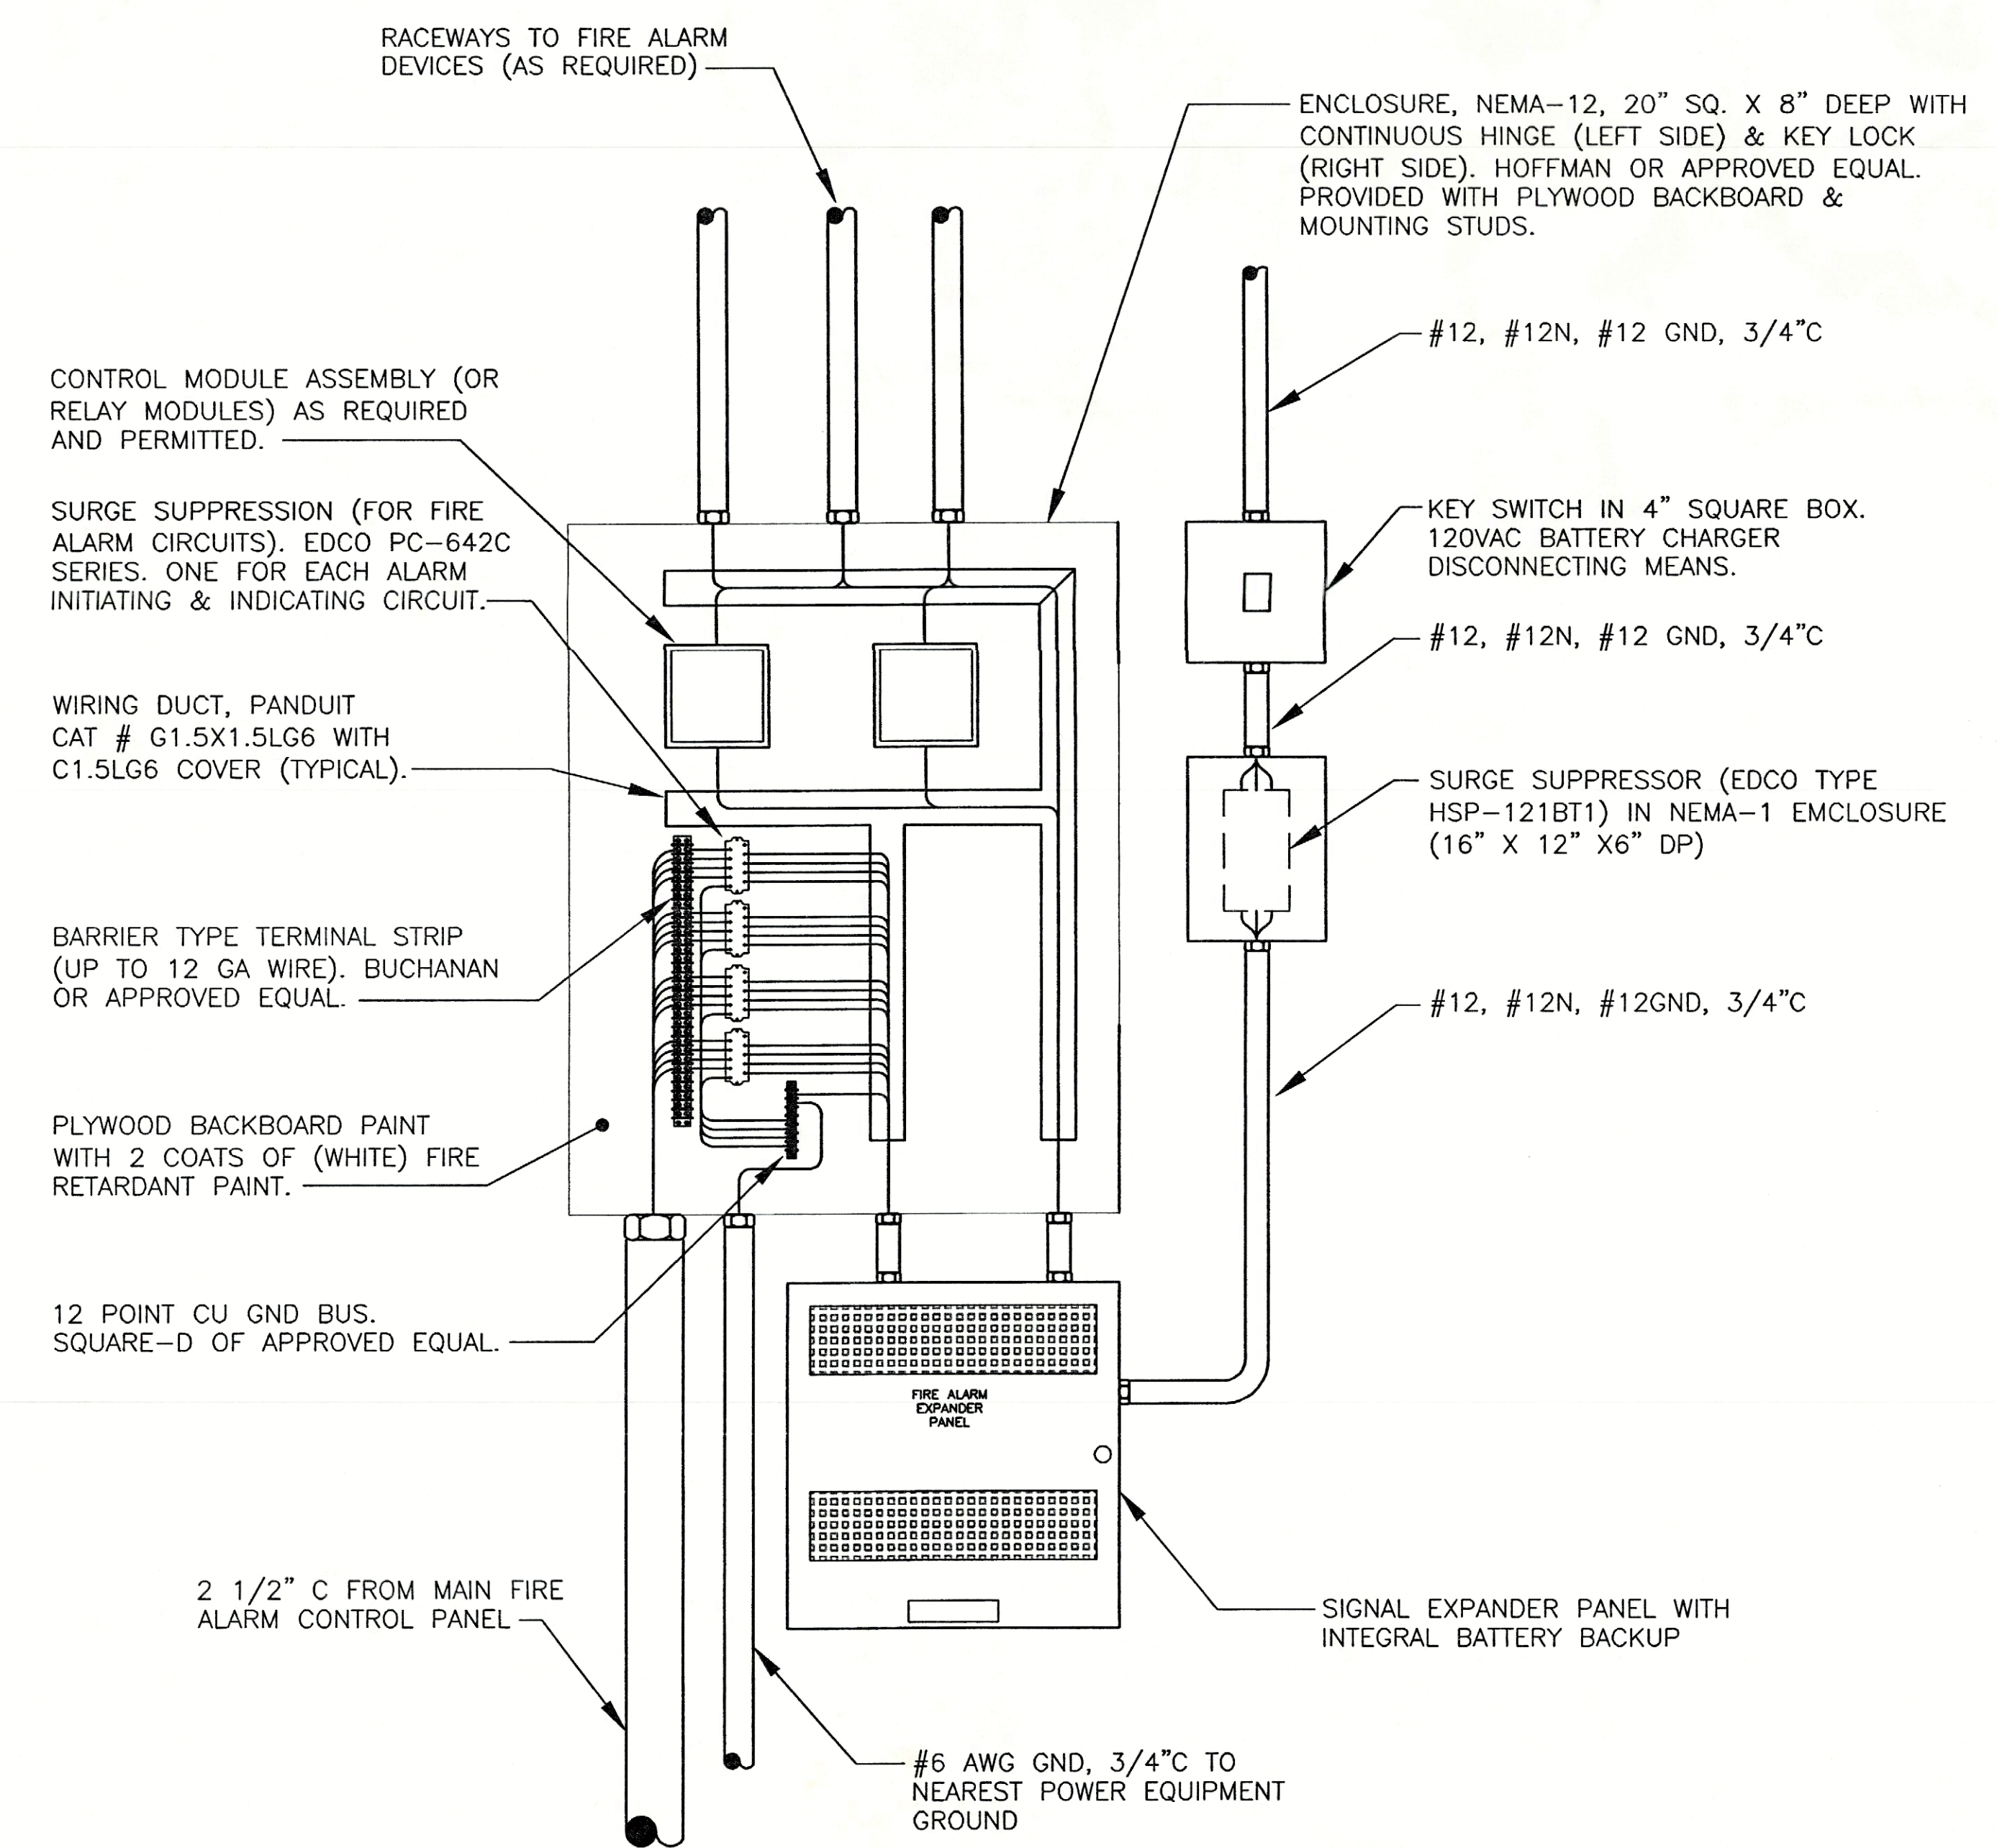

ALARM POWER MODULE DIAGRAM
NTS
NOTE: ALL FIRE ALARM INITIATING AND INDICATING CIRCUIT CONDUCTORS SHALL BE STRANDED (NO EXCEPTIONS).

BRPH ARCHITECTS ENGINEERS, INC.
MELBOURNE / ORLANDO / WEST PALM BEACH
3276 SUNTREE BOULEVARD
MELBOURNE, FLORIDA 32909
Phone: 321-255-1199
Fax: 321-255-1198
www.brph.com
Copyright © 2003
Board of Professional Engineers License No. 1439
These plans are the property of BRPH Architects Engineers, Inc. and may not be reproduced or used in any form without the written permission of BRPH Architects Engineers, Inc.


FIRE ALARM UPGRADES
LAKE COUNTY AREA VO-TECH
LAKE COUNTY SCHOOLS
FIRE ALARM RISER & DIAGRAMS

ARCH/ENGR OF RECORD
DESIGNED BY CARD
DRAWN BY CARD
CHECKED BY
PROJECT NO./CAD CODE 5206.10/E02
DATE 12-22-03
DRAWING NO. E-2
SHEET OF

NOTES:


16-1 EXISTING DUCT DETECTOR LOCATIONS. REPLACE EXISTING DETECTORS WITH NEW. PROVIDE NECESSARY EQUIPMENT TO ACCOMMODATE NEW DEVICES.

16-2 NEW FIRE ALARM PANEL LOCATION.

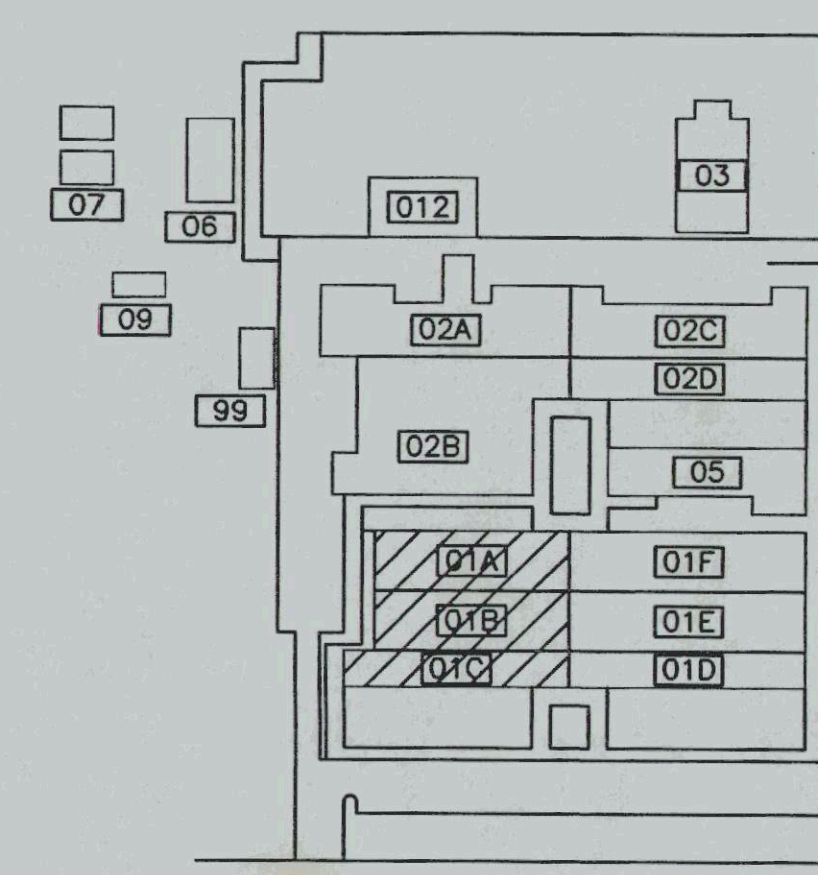

KEY PLAN

NTS

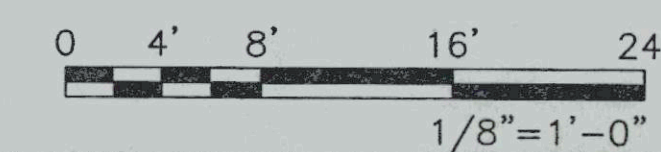

BLDG 01A,01B AND 01C - FIRE ALARM PLAN

$$1/8'' = 1'-0''$$


P:\5206-10\current\E04.dwg, Layout1, 12/22/2003 02:15:13 PM, dcard


A

B

C


D

E

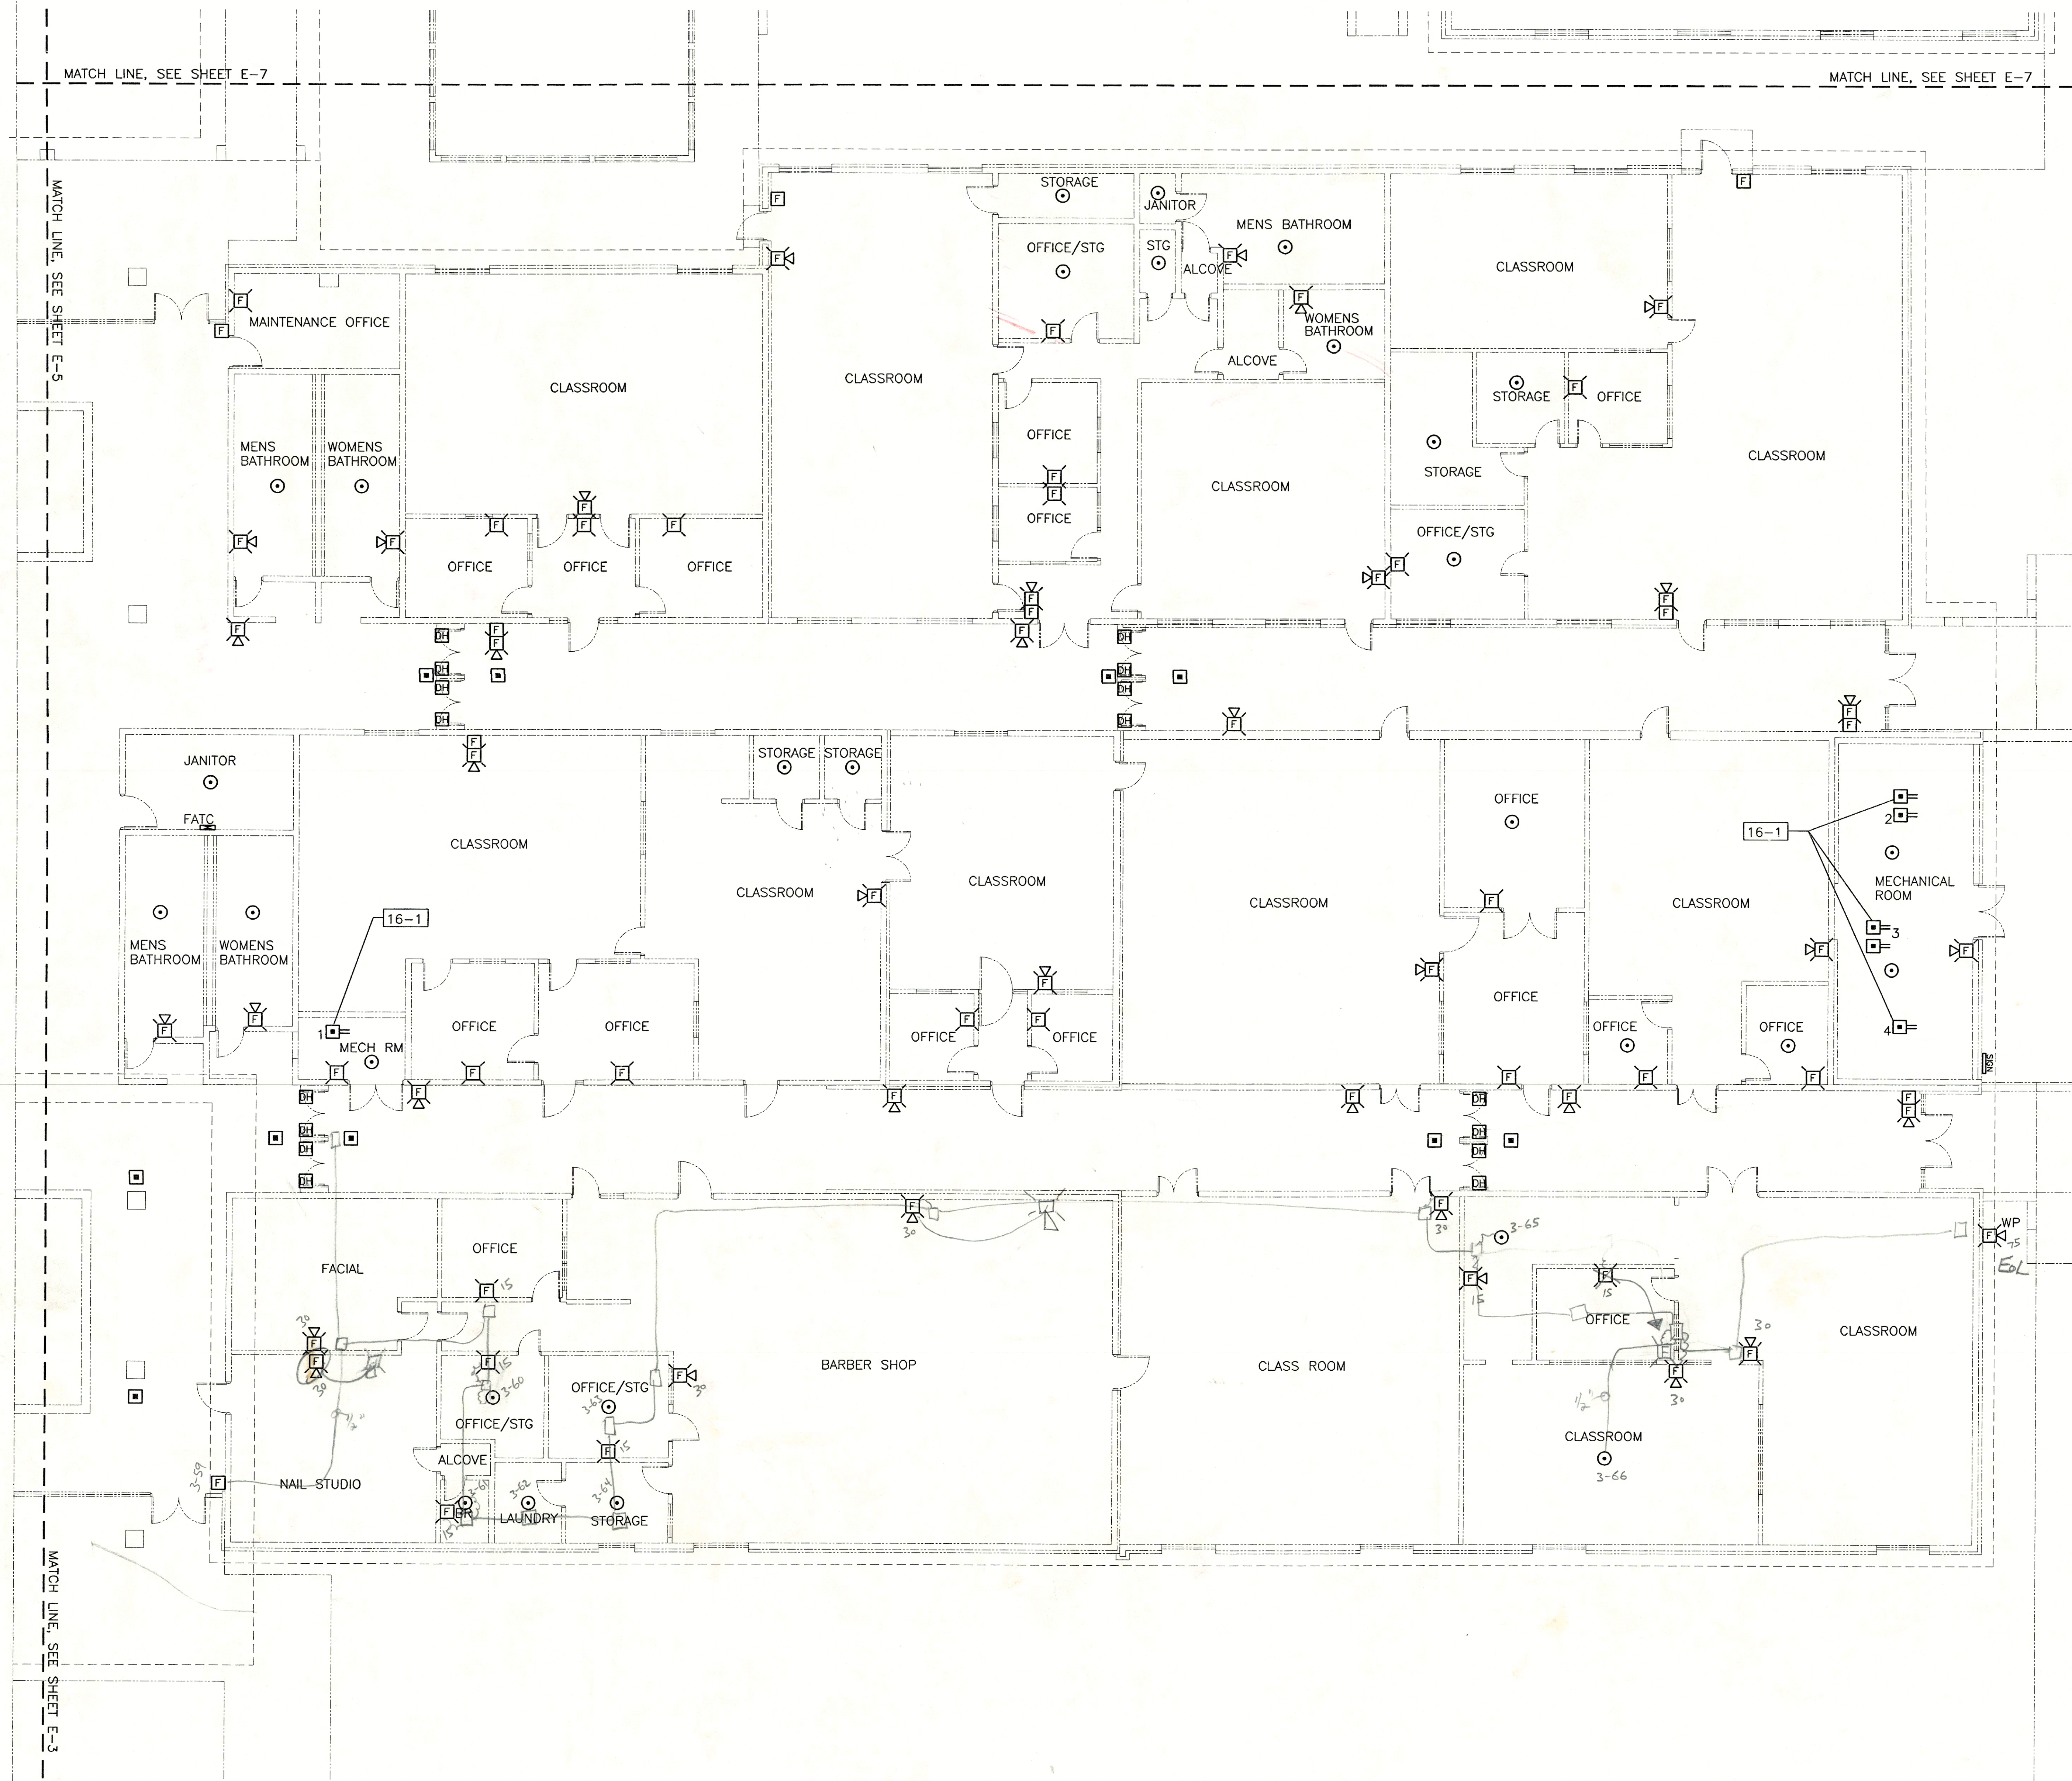

NOTES:

16-1 EXISTING DUCT DETECTOR LOCATIONS. REPLACE EXISTING DETECTORS WITH NEW. PROVIDE NECESSARY EQUIPMENT TO ACCOMMODATE NEW DEVICES.

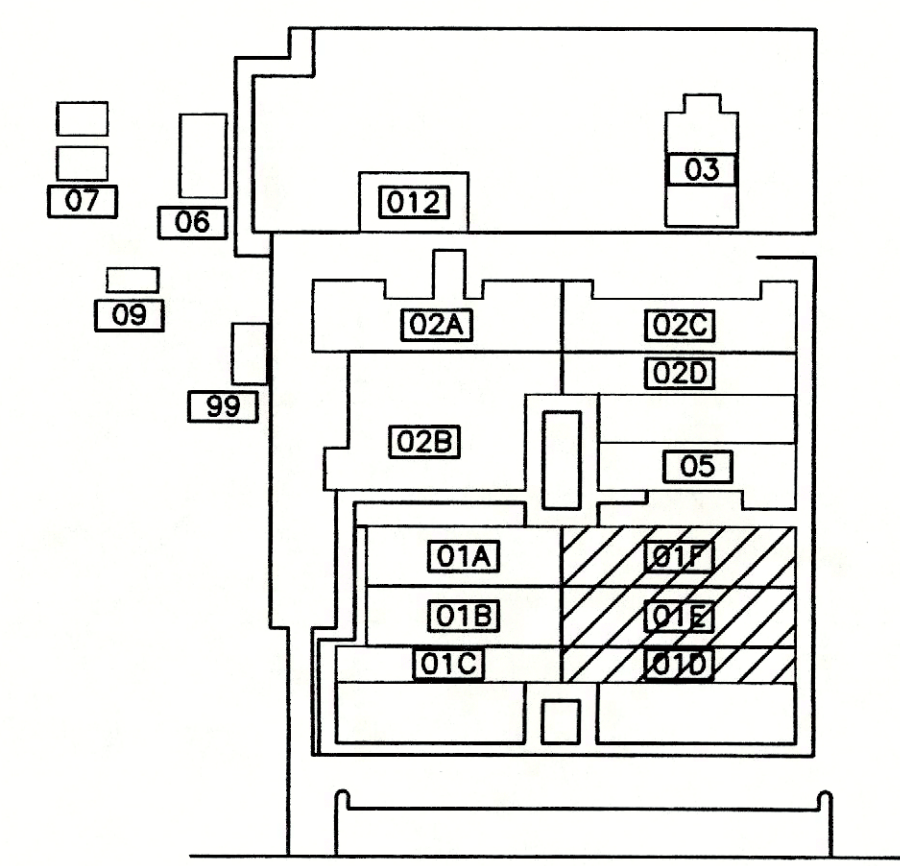

KEY PLAN

NTS
0 4' 8' 16' 24'
1/8" = 1'-0"


BLDG 01D,01E, AND 01F - FIRE ALARM PLAN
1/8" = 1'-0"

FIRE ALARM UPGRADES
LAKE COUNTY AREA VO-TECH
LAKE COUNTY SCHOOLS
BLDG 01D,01E & 01F FIRE ALARM PLAN

BRPH ARCHITECTS ENGINEERS, INC.
MELBOURNE / ORLANDO / WEST PALM BEACH
3275 SUNTREE BOULEVARD
MELBOURNE, FLORIDA 32940
Tel: 321.255.1111
Fax: 321.255.1112
www.brph.com
Board of Professional Engineers License No. 1439
Copyright © 2003
These plans and specifications are the property of BRPH Architects Engineers, Inc. and are not to be reproduced or used in any manner without the written consent of BRPH Architects Engineers, Inc.


ARCH/ENGR OF RECORD
DESIGNED BY
CARD
DRAWN BY
PRESSMAN
CHECKED BY
PROJECT NO./CAD CODE
5206.10/E04
DATE
12-22-03
DRAWING NO.
E-4
SHEET
OF

16-1	RECONNECT NEW FIRE ALARM SYSTEM TO EXISTING PAINT SPRAY BOOTH SHUTDOWN CONTROL.
16-2	PROVIDE OUTLET BOX AND CONDUCTORS, 80" ABOVE FINISHED FLOOR, FOR CONNECTION TO FUTURE PAINT SPRAY EQUIPMENT. VERIFY EXACT LOCATION WITH SHOP INSTRUCTOR.
16-3	PROVIDE AND INSTALL HAZARDOUS AREA HEAT DETECTOR. RELOCATE EXISTING FROM ROOM 103F TO ROOM 103E (NEW PAINT SHAKER ROOM) IF IT CAN BE MADE COMPATIBLE WITH NEW SYSTEM.

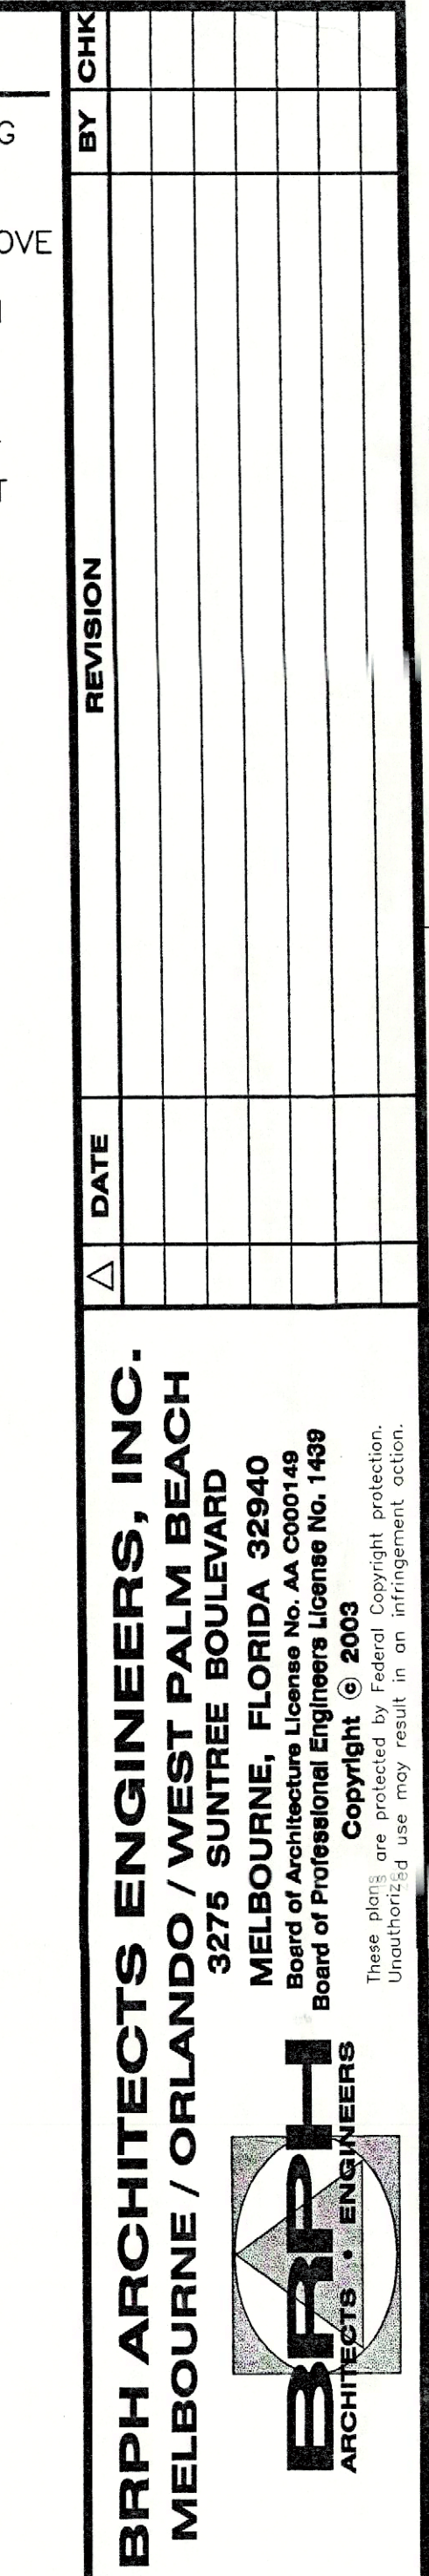

**FIRE ALARM UPGRADES
LAKE COUNTY AREA VO-TECH
LAKE COUNTY SCHOOLS**

BLDG 02A & 02C FIRE ALARM PLAN

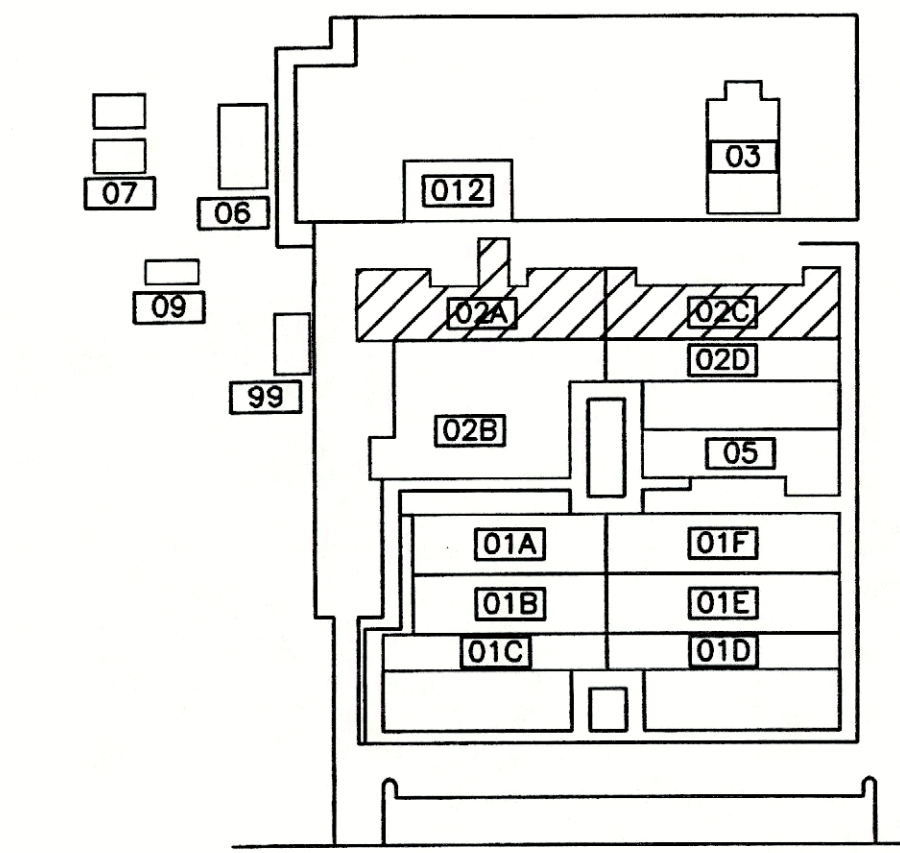

KEY PLAN


NTS




0 4' 8' 16' 24'


$1/8" = 1' - 0"$

- 16-1 GAS METER AND VALVE LOCATION. PROVIDE SOLENOID VALVE FOR AUTOMATIC SHUTOFF UPON FIRE ALARM SYSTEM ACTIVATION.
- 16-2 RECONNECT NEW FIRE ALARM SYSTEM TO EXISTING KITCHEN HOOD SHUTDOWN CONTROLS.
- 16-3 EXISTING DUCT DETECTOR LOCATIONS. REPLACE EXISTING DETECTORS WITH NEW. PROVIDE NECESSARY EQUIPMENT TO ACCOMMODATE NEW DEVICES.

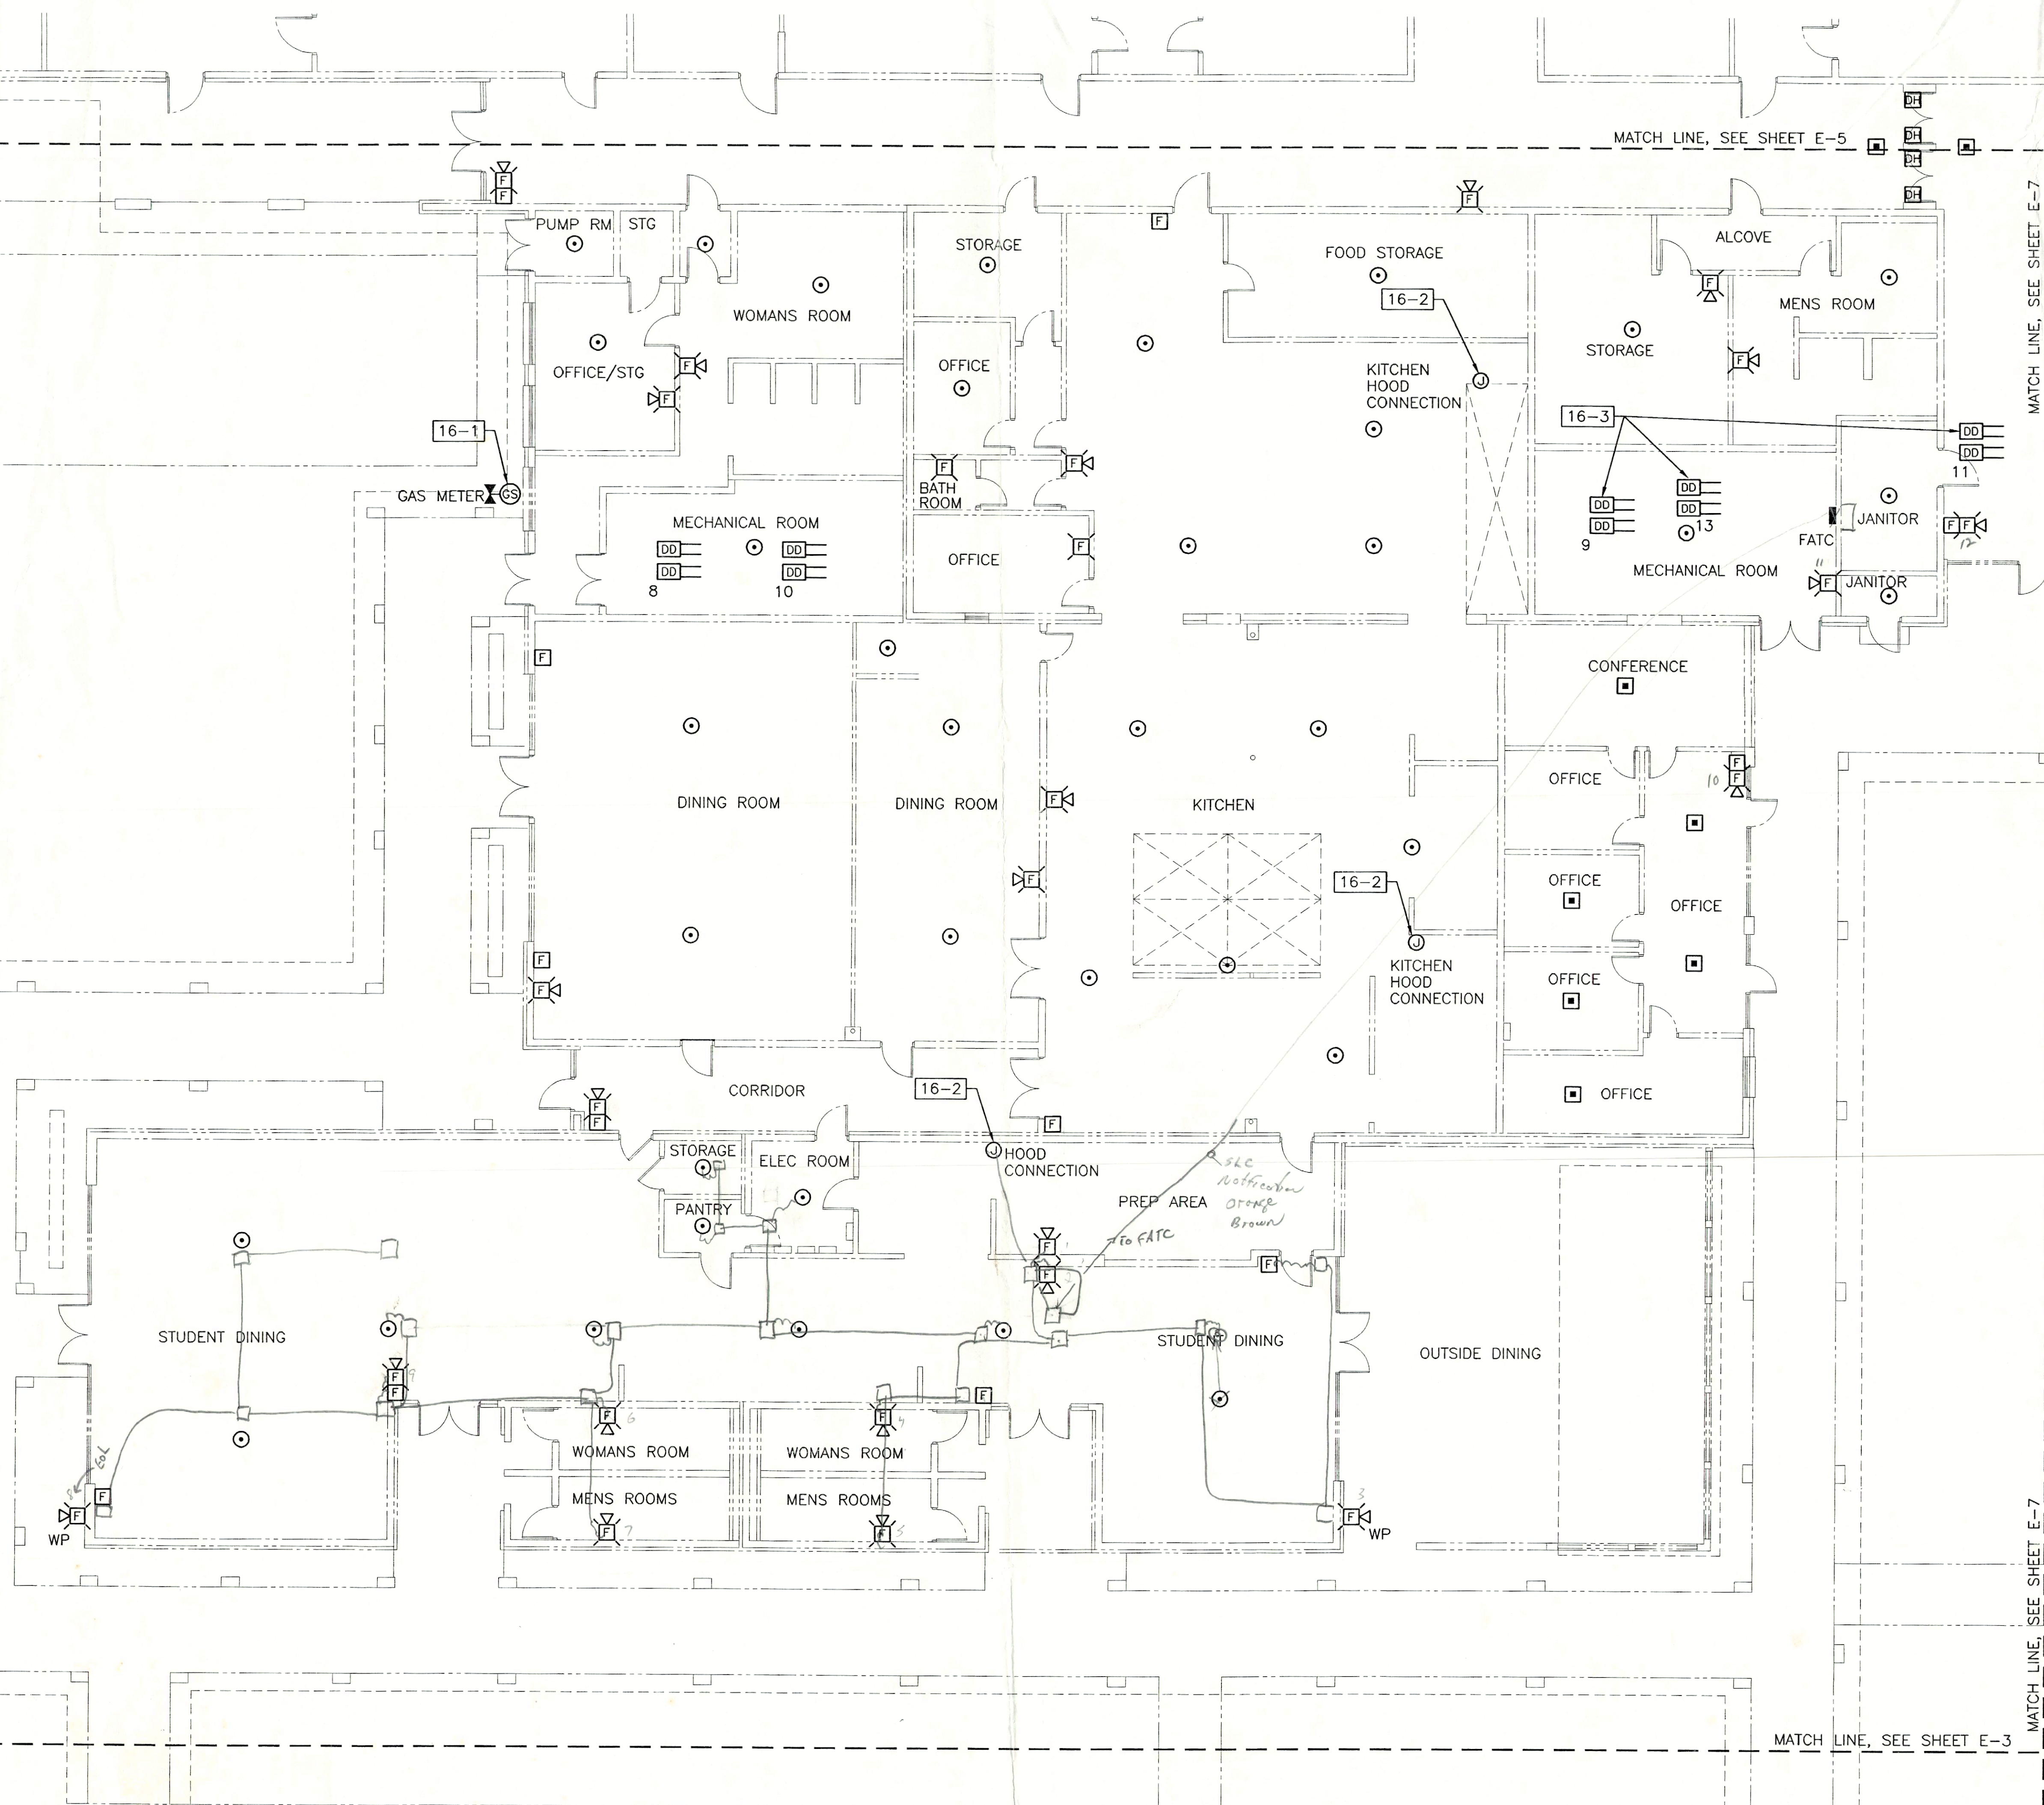
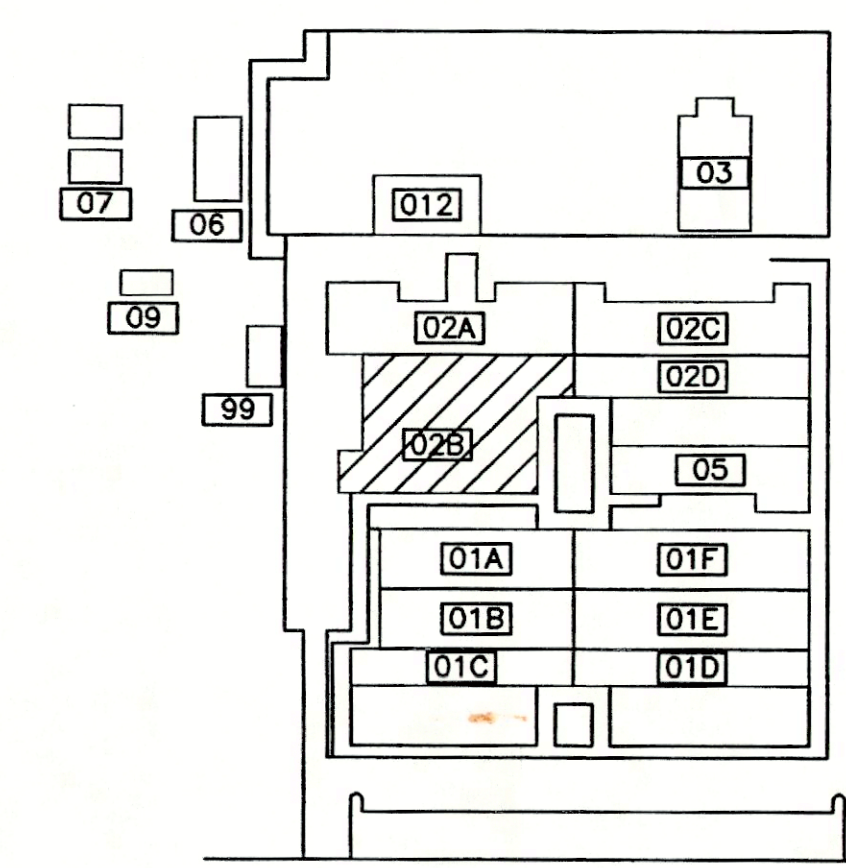
$$1/8'' = 1'-0''$$


NTS

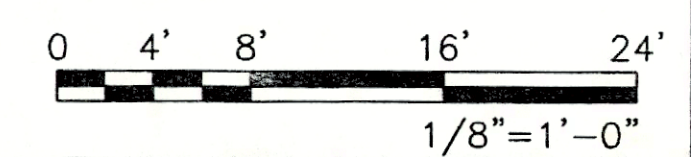

BRPH ARCHITECTS ENGINEERS, INC.
MELBOURNE / ORLANDO / WEST PALM BEACH
3275 SUNTREE BOULEVARD

MELBOURNE, FLORIDA 32940
Board of Architecture License No. AA C000149
Board of Professional Engineers License No. 1439
Copyright © 2003

BRPI
ARCHITECTS • ENGINEERS

FIRE ALARM UPGRADES
LAKE COUNTY AREA VO-TECH
LAKE COUNTY SCHOOLS

BLDG 02B FIRE ALARM PLAN

ARCH/ENGR OF RECORD

DESIGNED BY
CARD

DRAWN BY
PRESSMAN

CHECKED BY

PROJECT NO./CAD CODE
5206.10/E06


DATE
12-22-03

DRAWING NO.
E-6

SHEET OF


NOTES:

16-1 GAS METER AND VALVE LOCATION. PROVIDE SOLENOID VALVE FOR AUTOMATIC SHUTOFF UPON FIRE ALARM SYSTEM ACTIVATION.

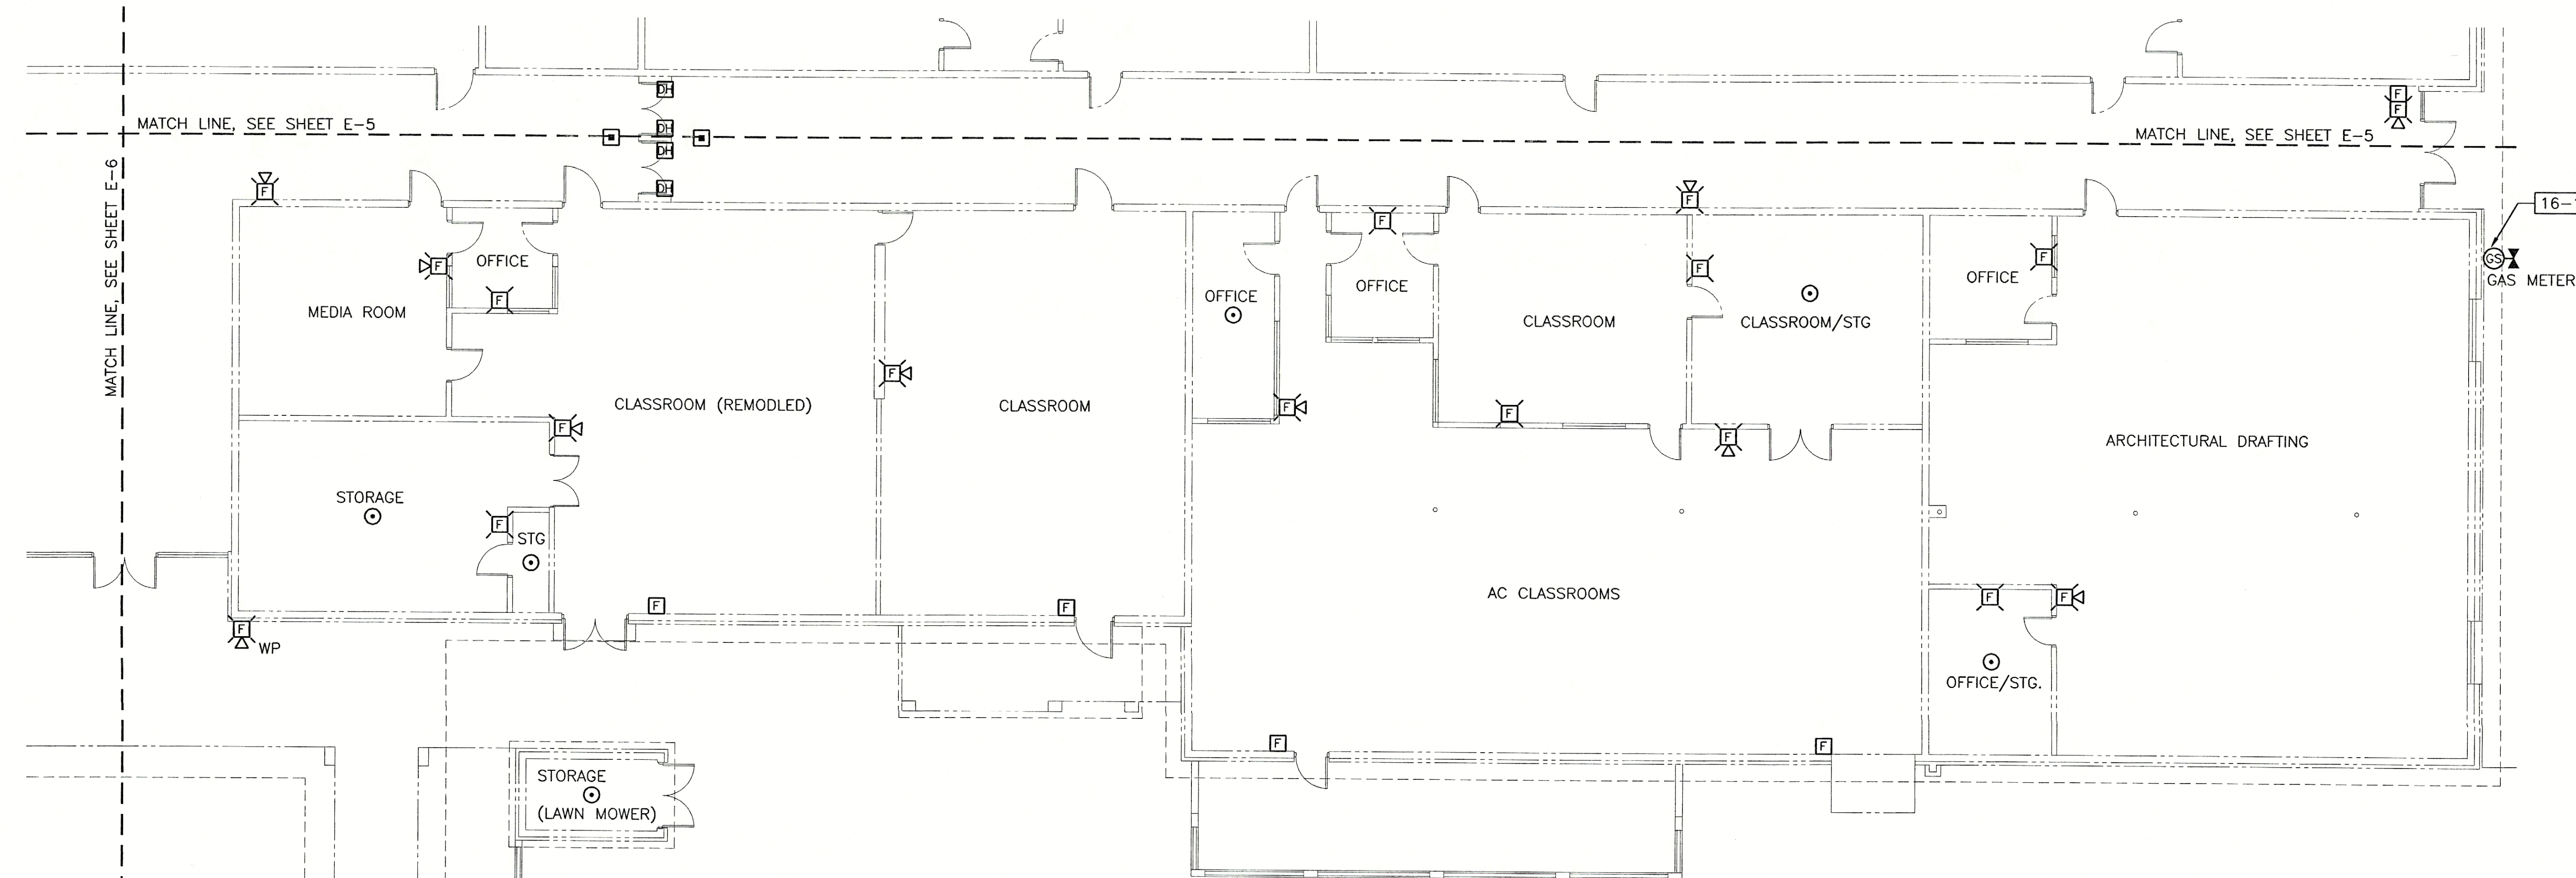


BLDG 02D - FIRE ALARM PLAN

1/8" = 1'-0"

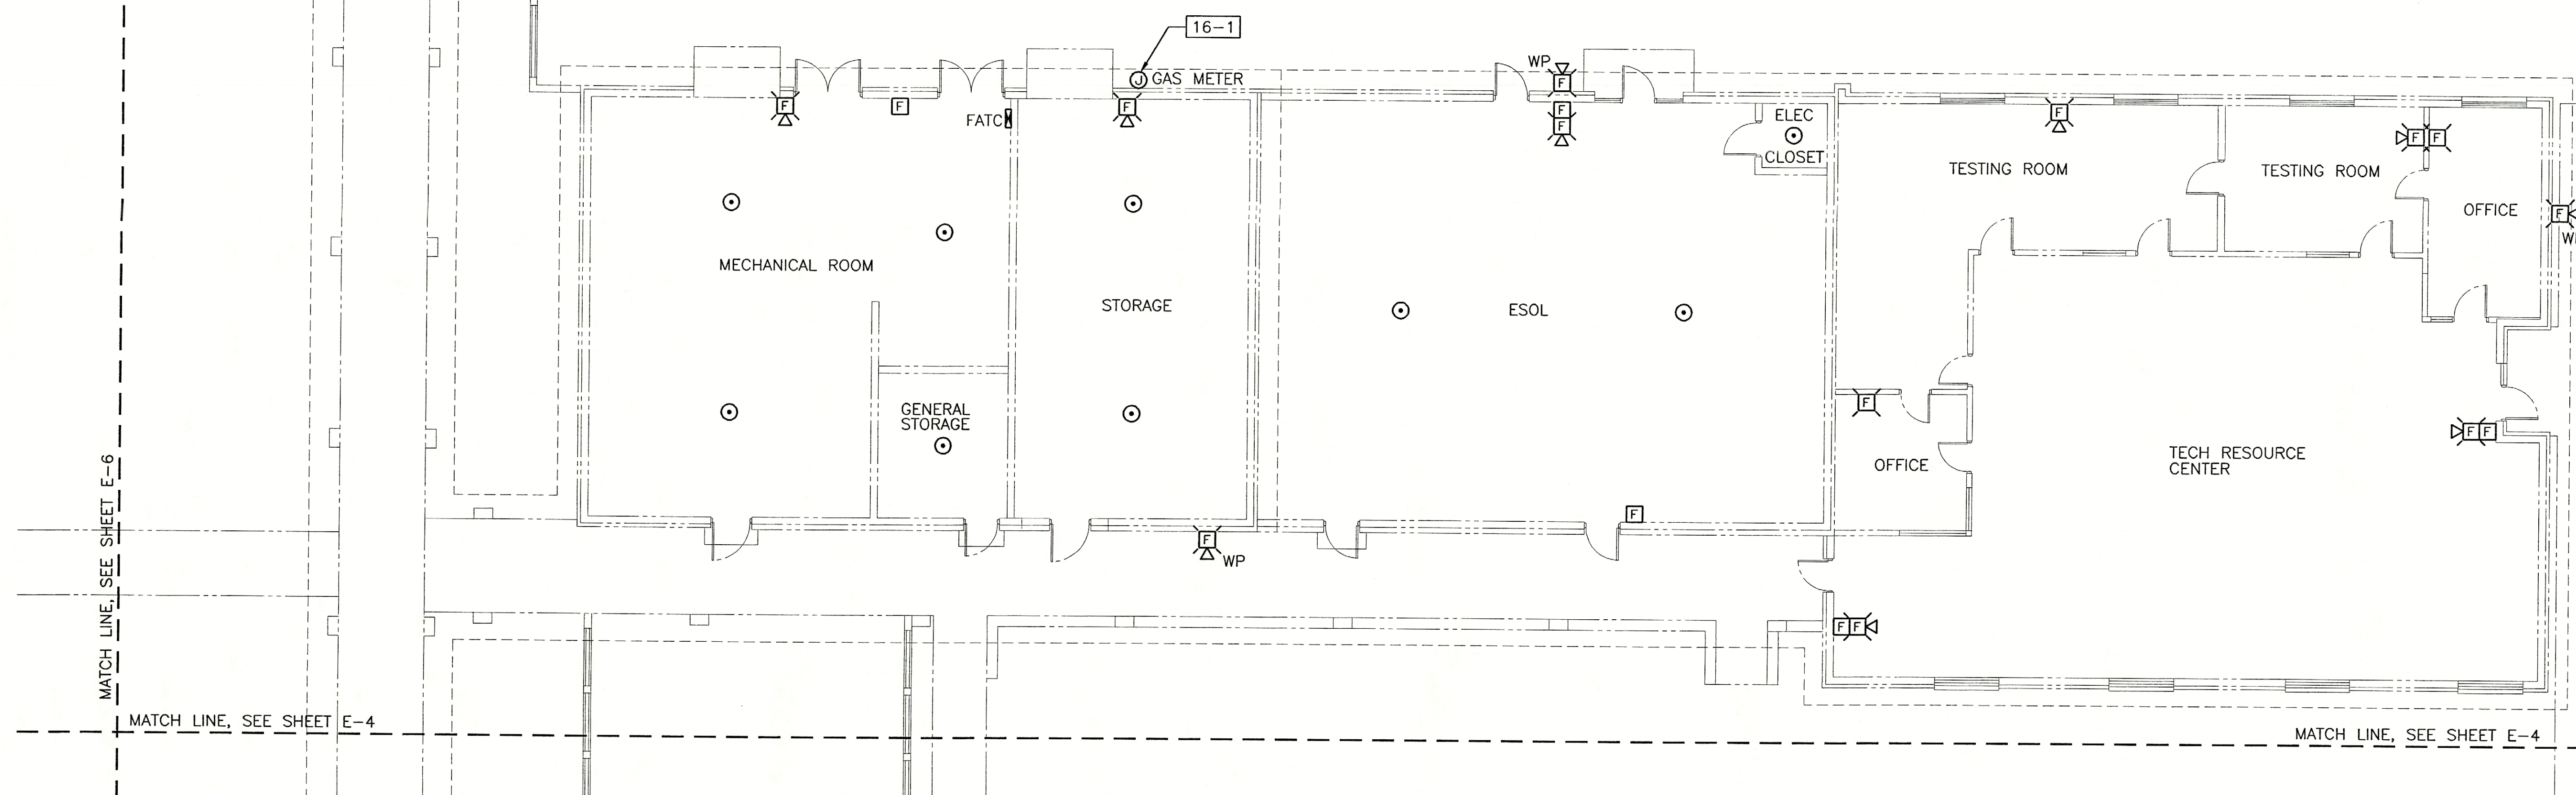

BLDG 05 - FIRE ALARM PLAN

1/8" = 1'-0"

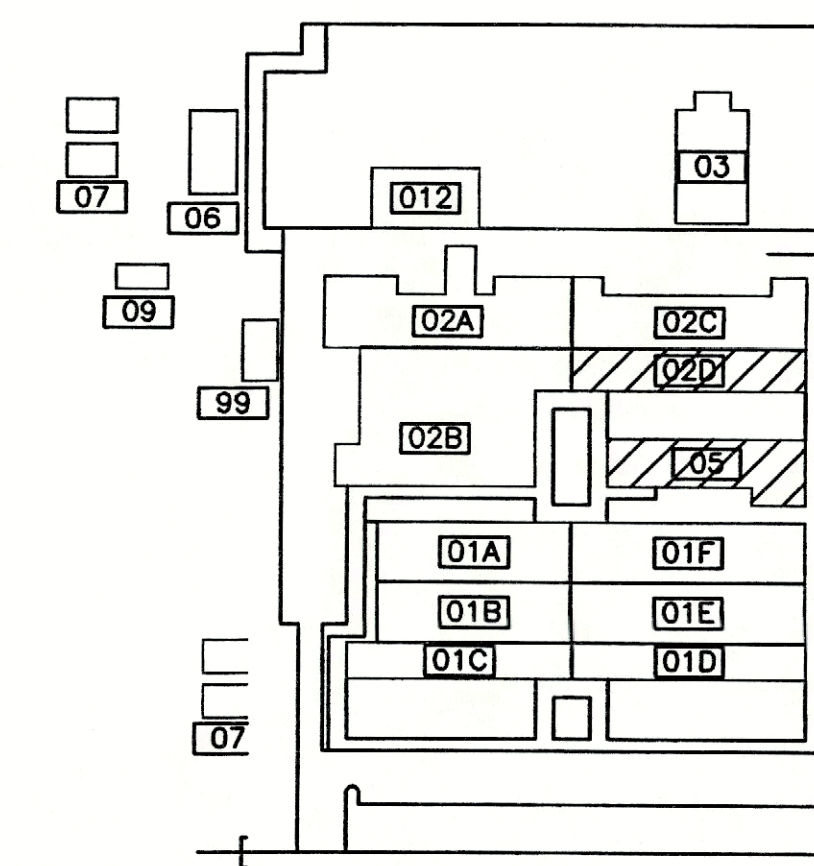

KEY PLAN



NTS

0 4' 8' 16' 24'
1/8" = 1'-0"

BRPH ARCHITECTS ENGINEERS, INC.
MELBOURNE / ORLANDO / WEST PALM BEACH
3275 SUNTREE BOULEVARD
MELBOURNE, FLORIDA 32940
Tel: 321.255.1100
Fax: 321.255.1101
www.brph.com
Copyright © 2003
Board of Professional Engineers License No. 1439
These plans are the property of BRPH Architects Engineers.
Unauthorized use may result in an infringement action.

FIRE ALARM UPGRADES
LAKE COUNTY AREA VO-TECH
LAKE COUNTY SCHOOLS
BLDG 02D AND 5 FIRE ALARM PLAN

ARCH/ENGR OF RECORD
DESIGNED BY
CARD
DRAWN BY
PRESSMAN
CHECKED BY
PROJECT NO./CAD CODE
5206.10/E07
DATE
12-22-03
DRAWING NO.
E-7
SHEET OF

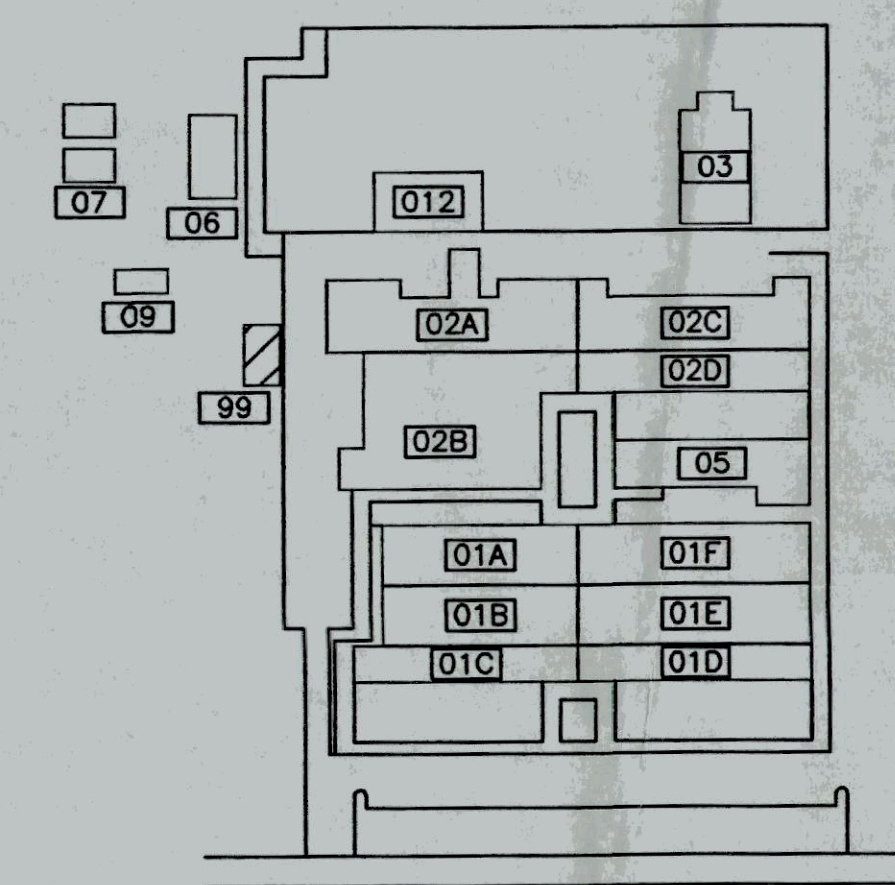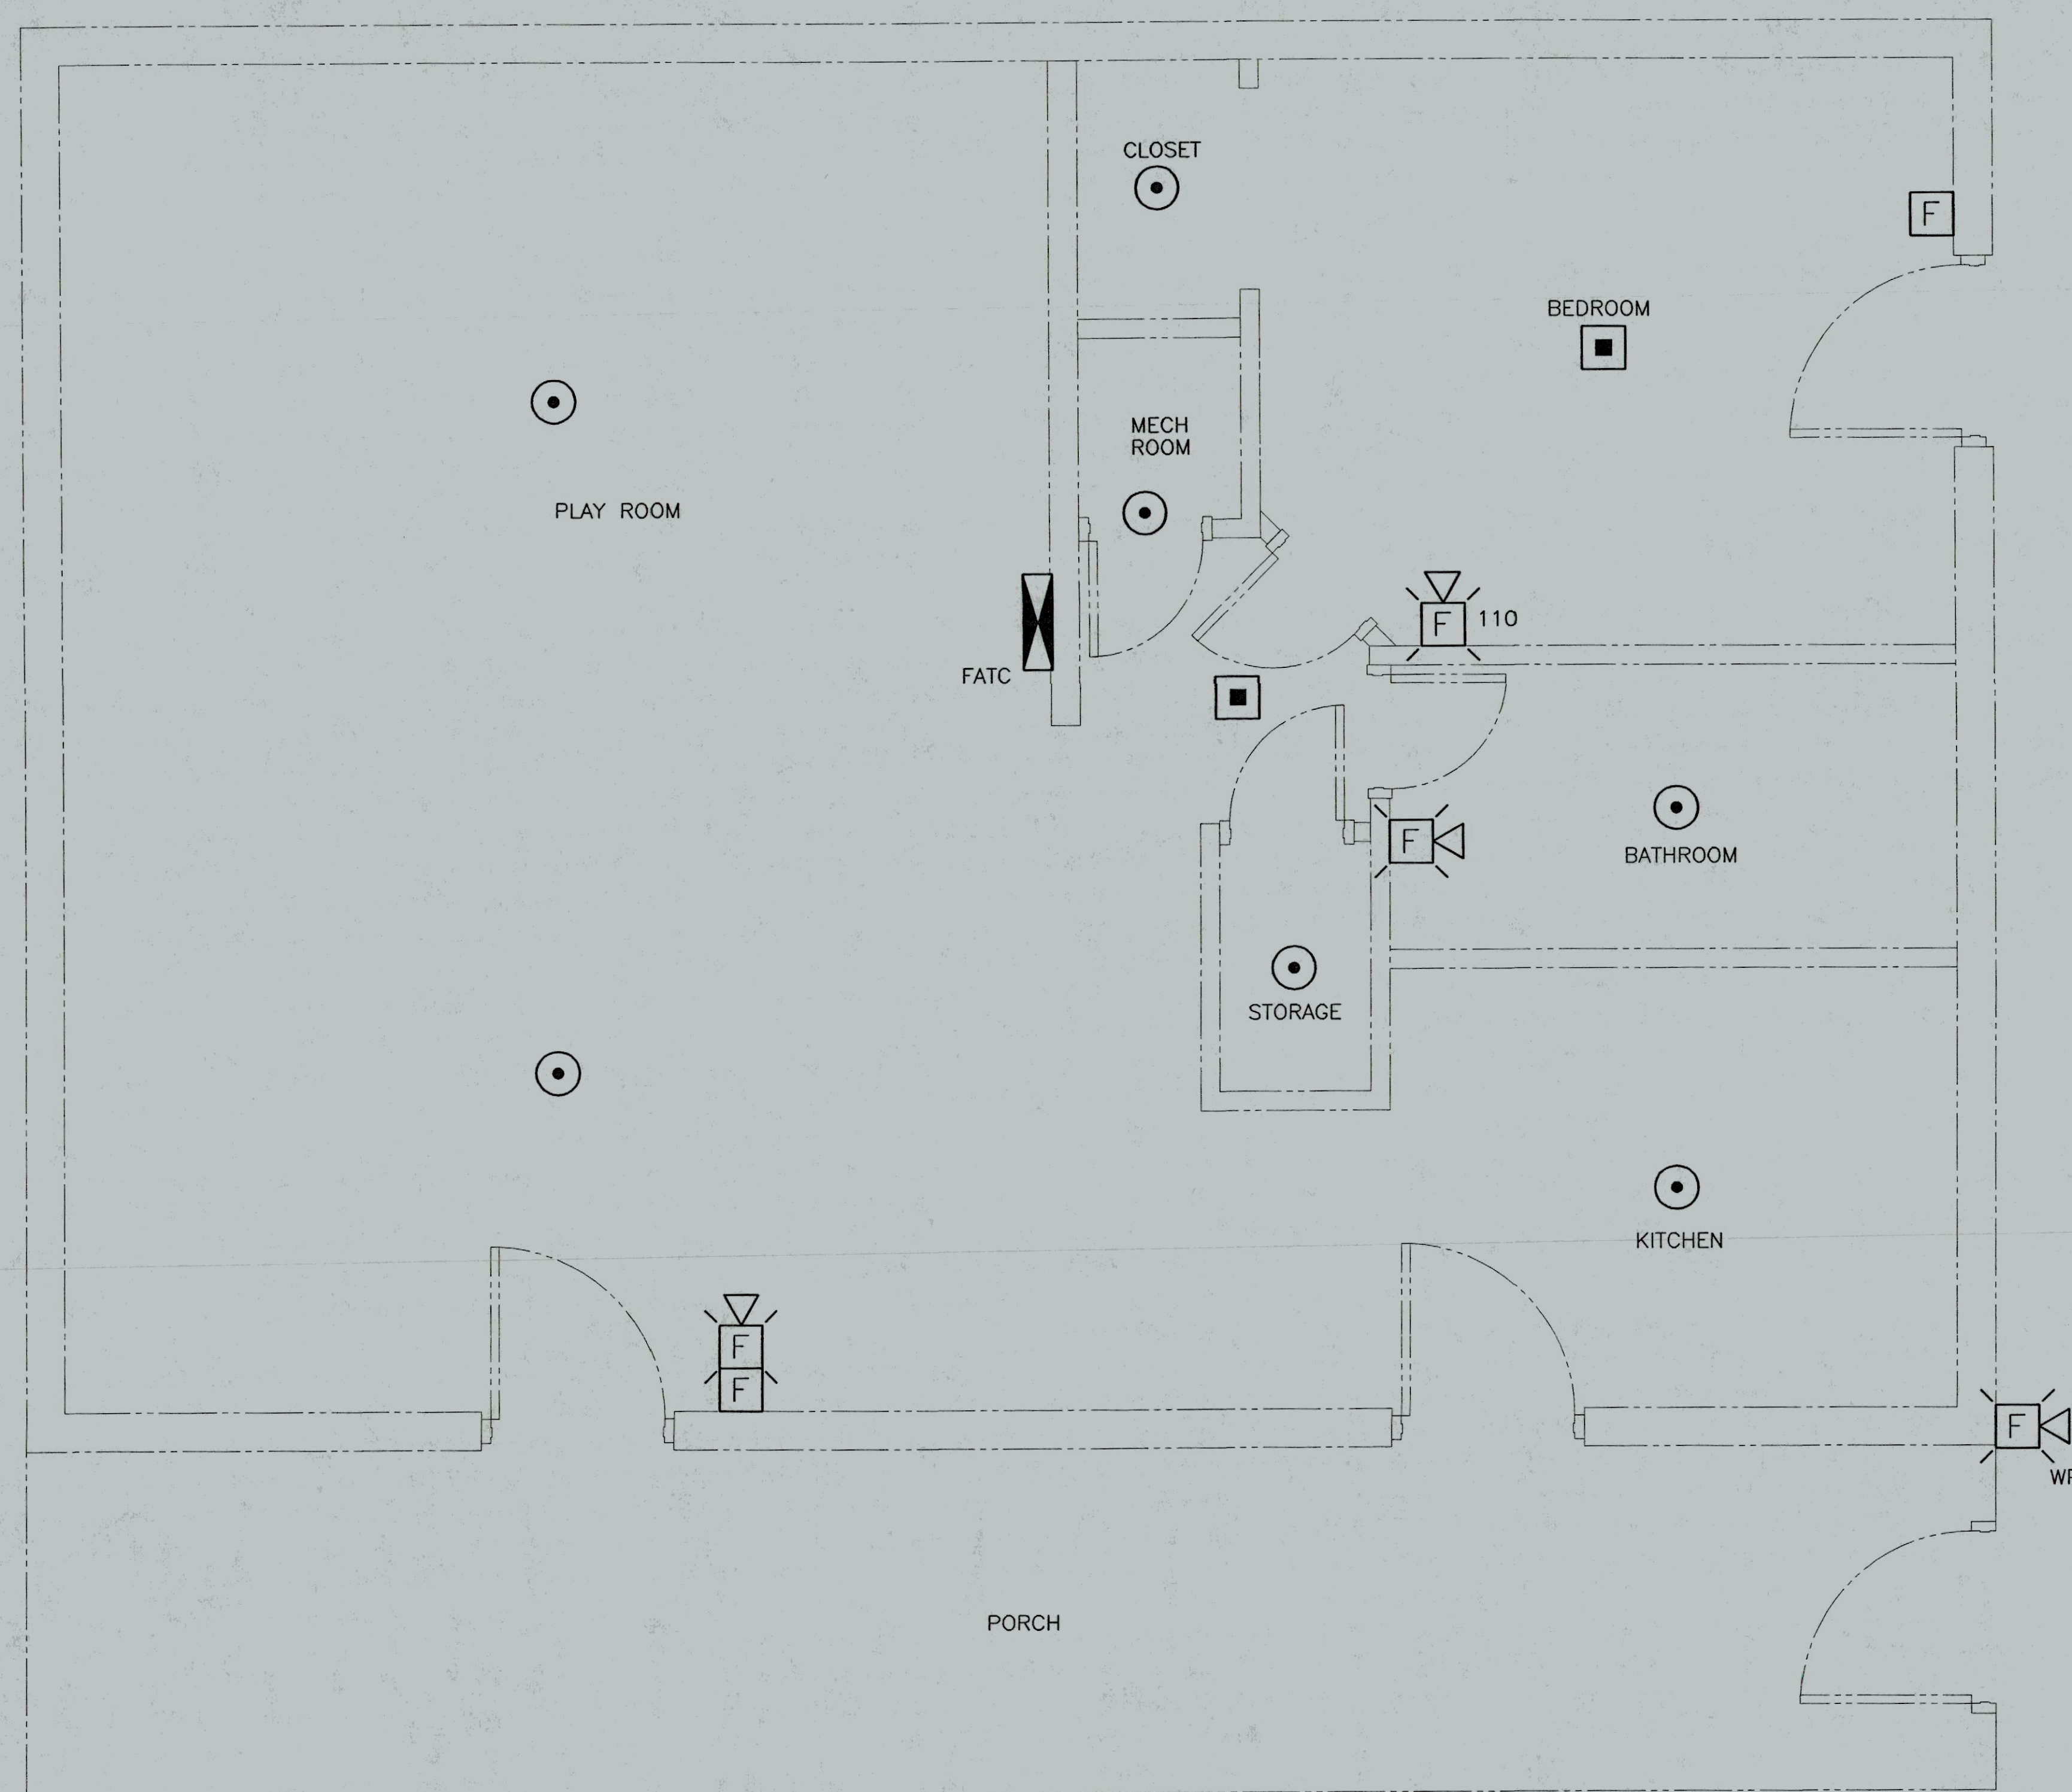

KEY PLAN



NTS

0 1' 2' 4'


1/2" = 1'



BLDG 99 - FIRE ALARM PLAN
1/2" = 1'-0"



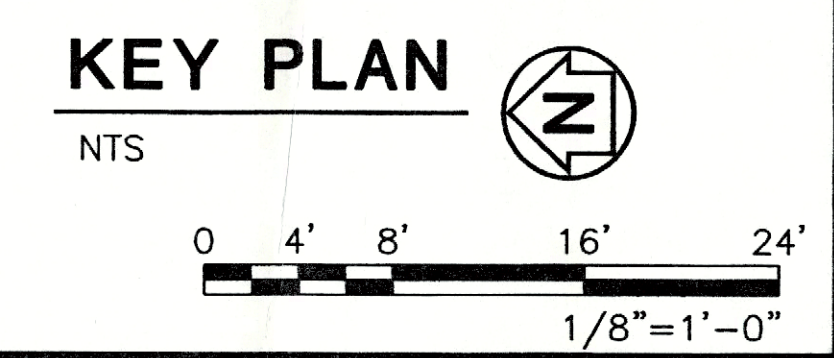
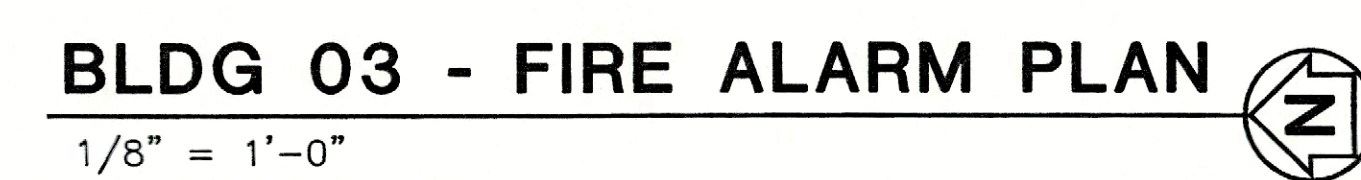


 - NOTES:**
-
- 16-1 GAS METER AND VALVE LOCATION. OWNER SHALL HAVE METER REMOVED AND VALVE LOCKED OFF.
- 16-2 PROVIDE HORN EXPANDER FOR FUTURE NEEDS.
- 16-3 UNDERGROUND CONDUIT FROM EXPANDER LOCATION IN BUILDING 3. LOCATE IN OPEN SHOP AS DIRECTED BY OWNER. PROVIDE JUNCTION BOX FOR FUTURE ACCESS.

FIRE ALARM UPGRADES LAKE COUNTY AREA VO-TECH LAKE COUNTY SCHOOLS		BRPH ARCHITECTS ENGINEERS, INC. MELBOURNE / ORLANDO / WEST PALM BEACH 3275 SUNTREE BOULEVARD MELBOURNE, FLORIDA 32940 Board of Architecture License No. 1A 000148 Florida Professional Seal No. 1489 Copyright © 2003		DATE BY
BLDG 03- FIRE ALARM PLAN				REVISION
ARCH/ENGR OF RECORD		DESIGNED BY CARD		
DRAWN BY J. PRESSMAN		CHECKED BY		
PROJECT NO./CAD CODE 5206.10/E09		DATE 12--22--03		
DRAWING NO. E-9		SHEET OF		

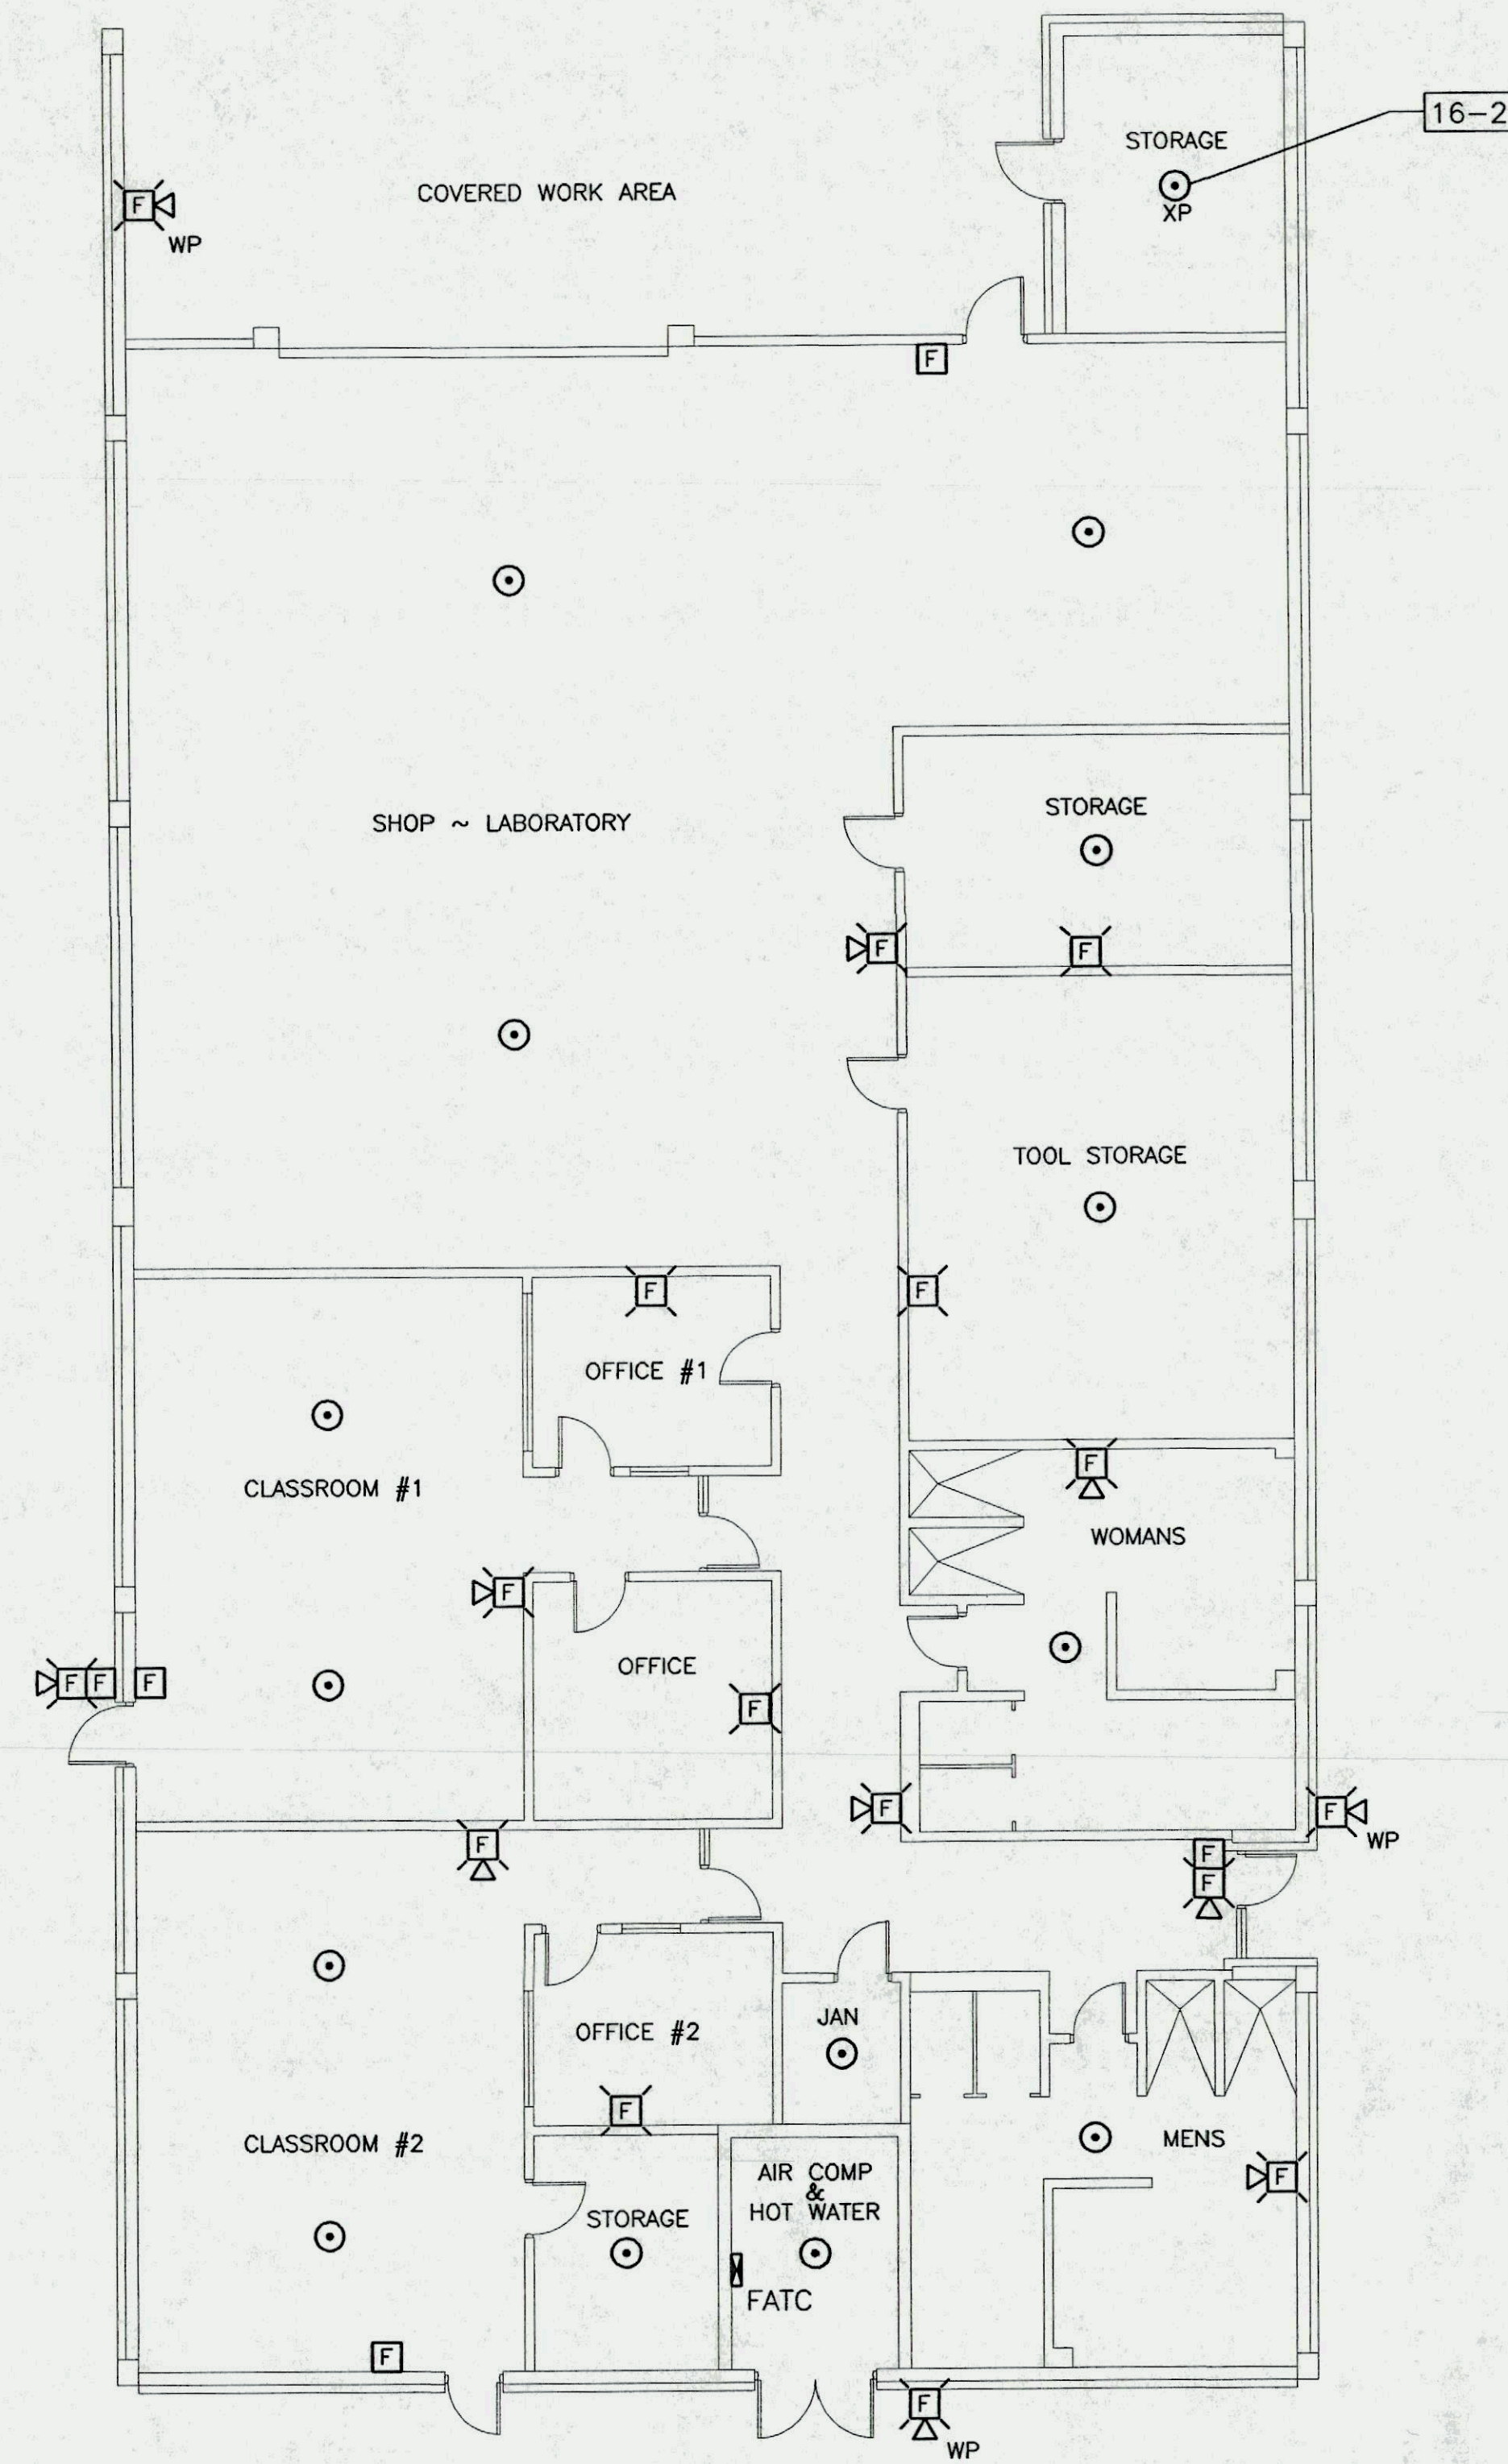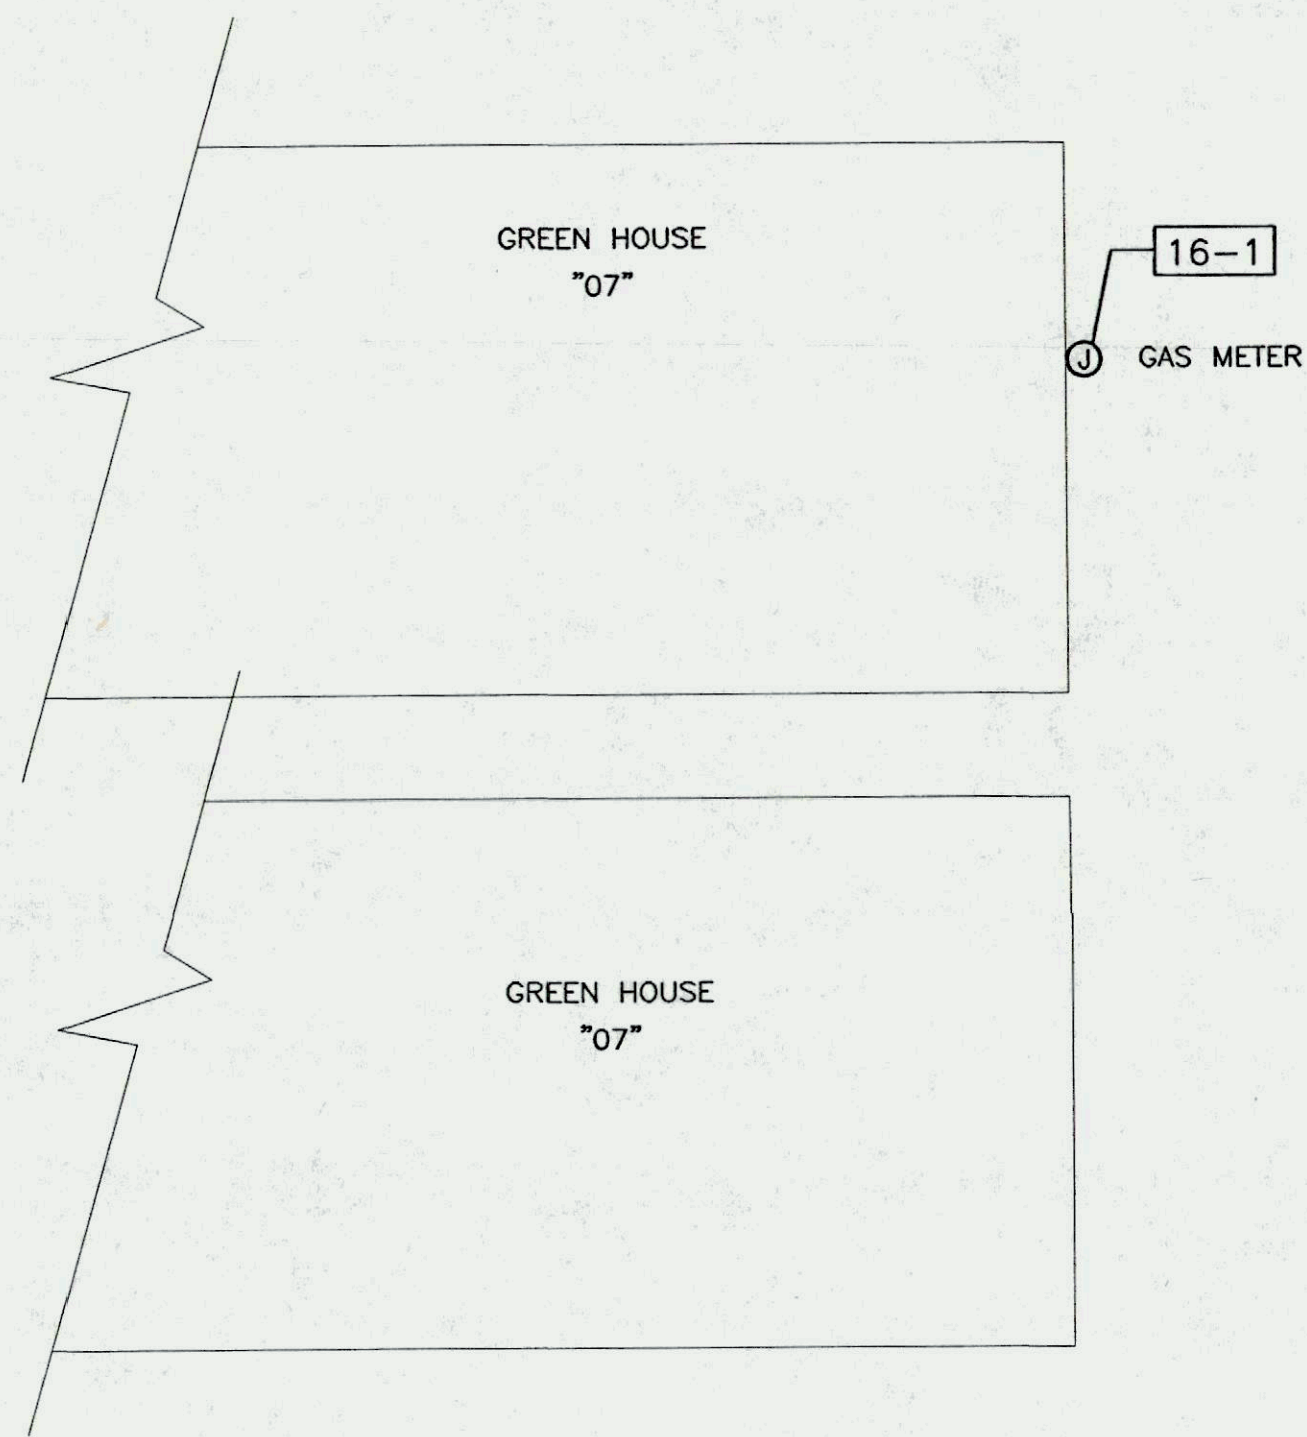


BLDG 06 - FIRE ALARM PLAN
1/8" = 1'-0"

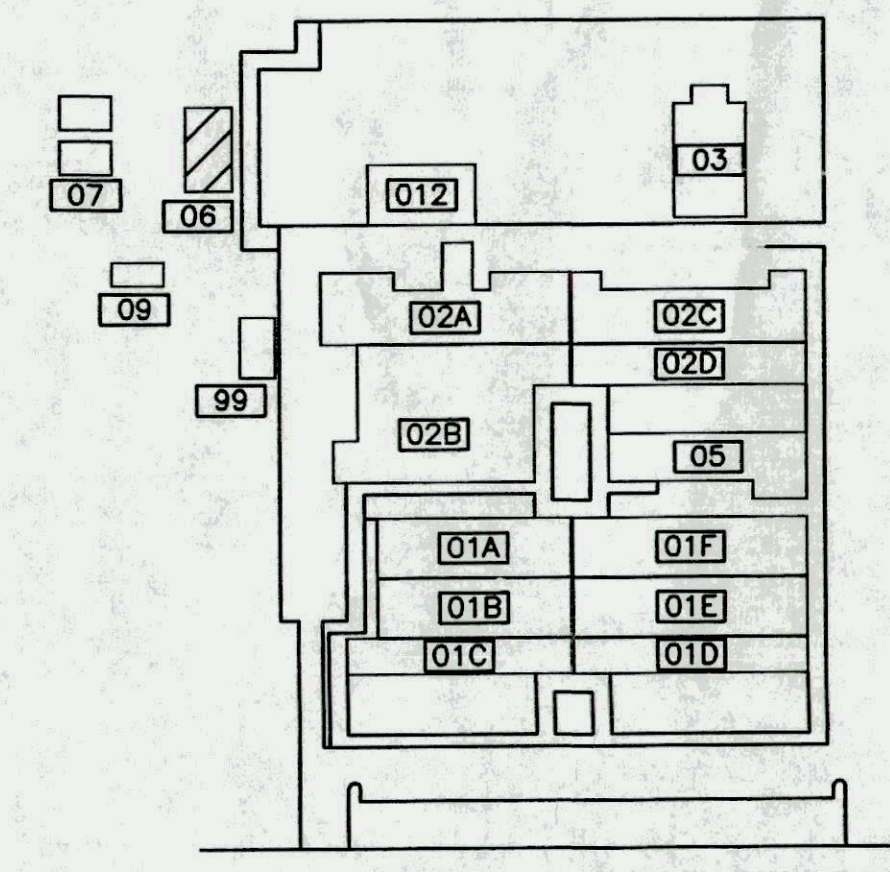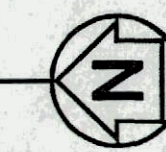

KEY PLAN

NTS

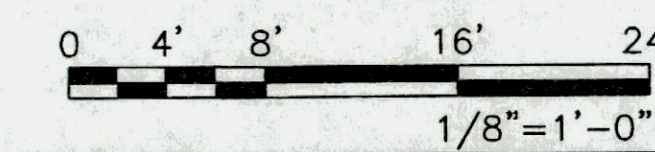

NOTES:

- 16-1 GAS METER AND VALVE LOCATION. OWNER SHALL HAVE METER REMOVED AND VALVE LOCKED OFF.
- 16-2 PROVIDE NECESSARY ACCESSORIES TO MAKE EXISTING HAZARD AREA HEAT DETECTOR ADDRESSABLE OR REPLACE TO MATCH NEW SYSTEM REQUIREMENTS.

BRPH ARCHITECTS ENGINEERS, INC.
MELBOURNE / ORLANDO / WEST PALM BEACH
3276 SUNTREE BOULEVARD
MELBOURNE, FLORIDA 32940
BRPH ARCHITECTS ENGINEERS
Board of Professional Engineers License No. 1439
Copyright © 2003
Unauthorized use may result in an infringement action.

FIRE ALARM UPGRADES
LAKE COUNTY AREA VO-TECH
LAKE COUNTY SCHOOLS
BLDG 06- FIRE ALARM PLAN

ARCH/ENGR OF RECORD
DESIGNED BY
CARD
DRAWN BY
J. PRESSMAN
CHECKED BY
PROJECT NO./CAD CODE
5206.10/E10
DATE
12-22-03
DRAWING NO.
E-10
SHEET
OF