


NAME: c:\drawings\9609\olevotec\9609A4-3.DWG DATE: JAN 08, 1997 TIME: 4:09 PM

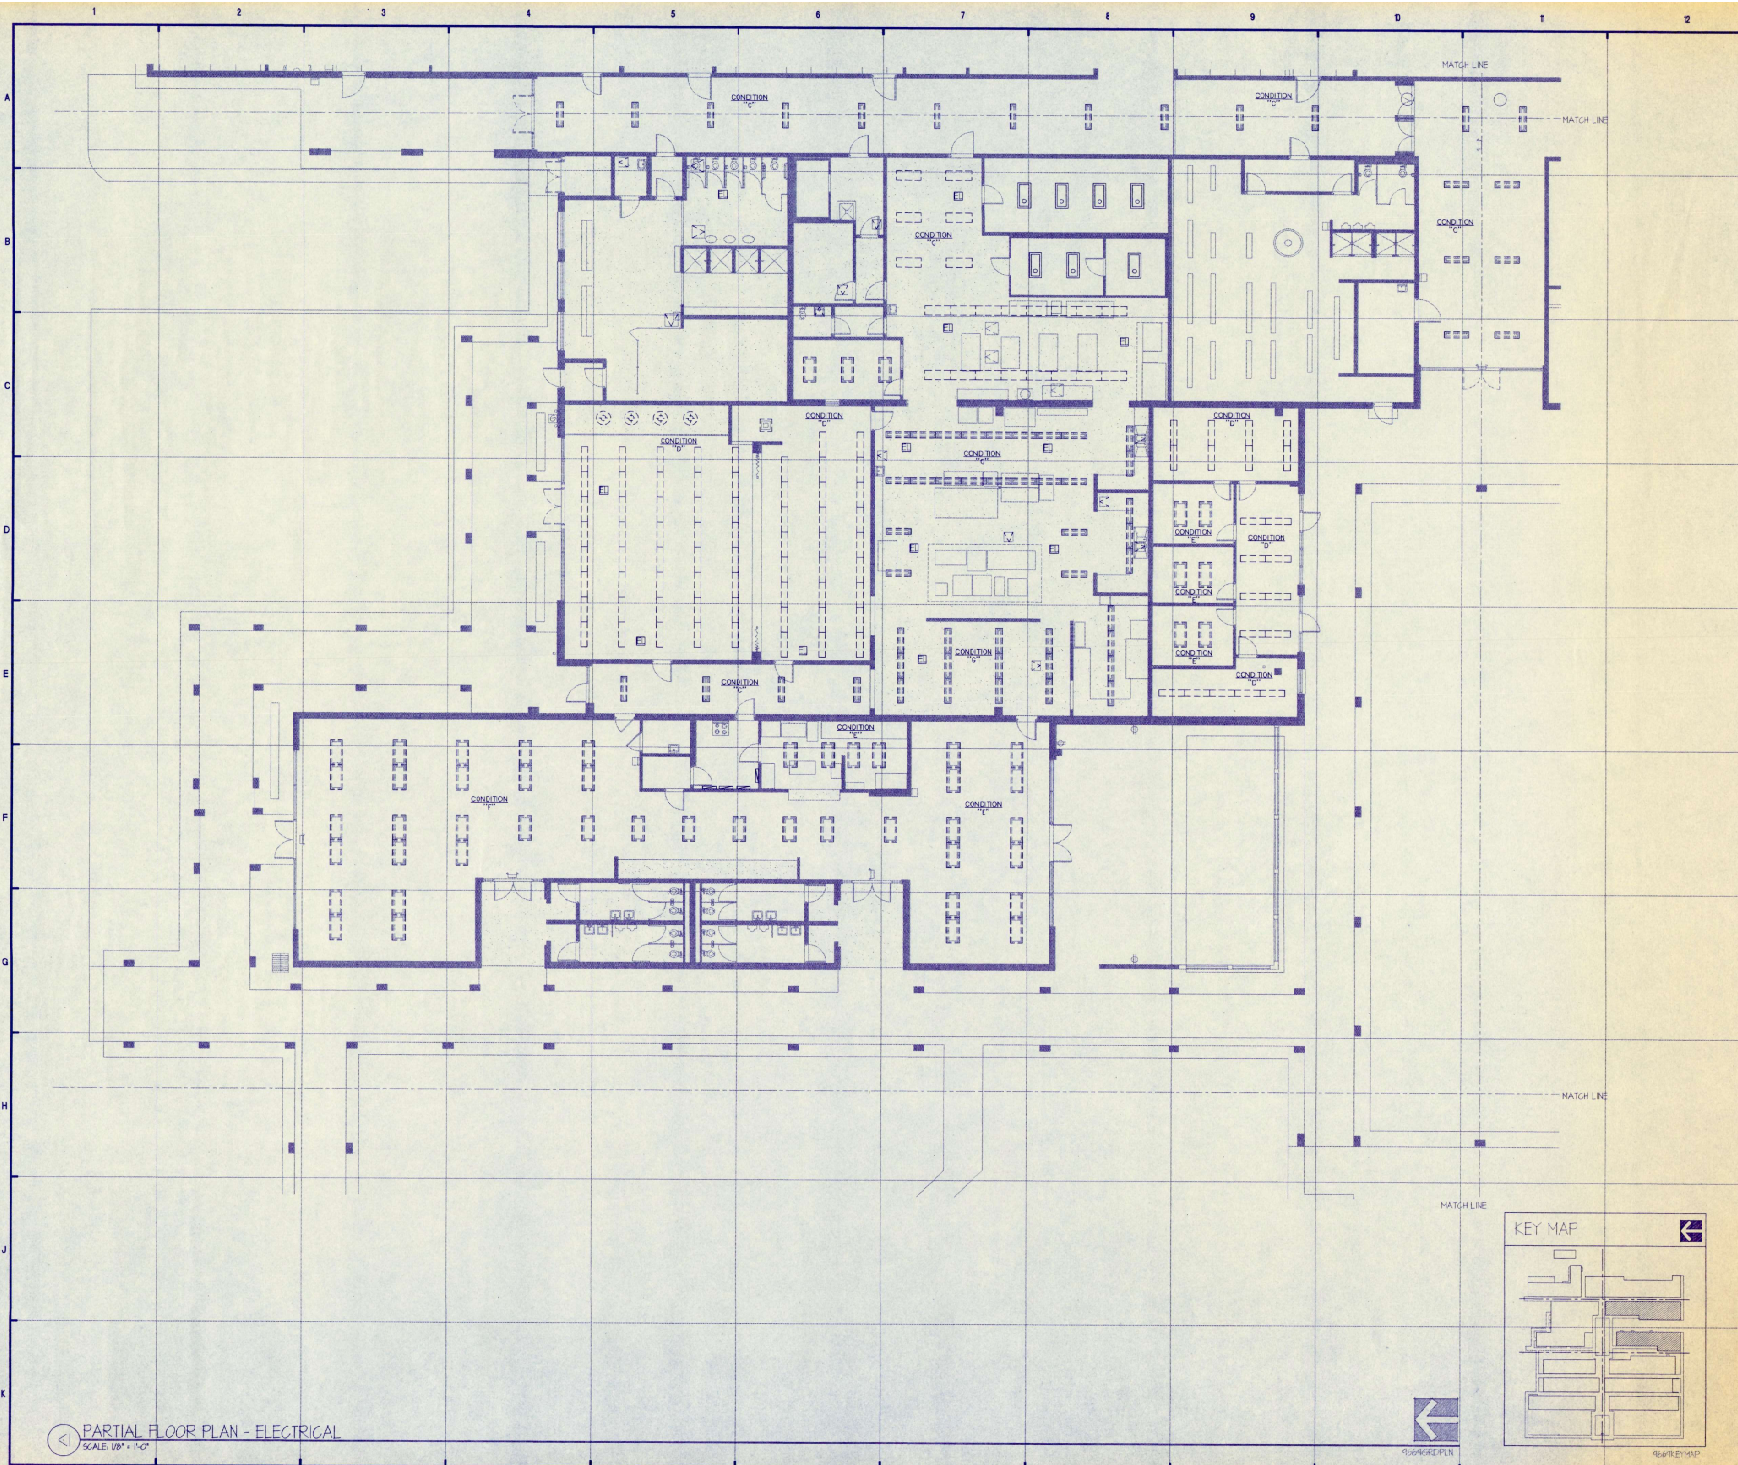

PARTIAL FLOOR PLAN - ELECTRICAL
SCALE: 1/8" = 1'-0"

BURKE, BALES & MILLS ASSOCIATES, INC. does not warrant the accuracy or completeness of this drawing. It is the property of BURKE, BALES & MILLS ASSOCIATES, INC. and is not to be reproduced, stored in a retrieval system, or transmitted in any form or by any means, electronic, mechanical, photocopying, recording, or by any information storage and retrieval system, without the prior written permission of BURKE, BALES & MILLS ASSOCIATES, INC.

NOTES

PREVIOUS LIGHTING UPGRADES

SEE WRITTEN SCOPE OF WORK FOR DESCRIPTION AND RECOMMENDATIONS REGARDING PREVIOUS LIGHTING FIXTURE UPGRADES.

PRELIMINARY

NOT FOR CONSTRUCTION

Rev	Date	Revised By



BURKE, BALES & MILLS ASSOCIATES, INC.
ARCHITECTURE • PLANNING • INTERIOR DESIGN
341 N. Mulberry Ave., Suite 110 Northwood, FL 32911
(407) 822-4511 • FAX (407) 822-9975

GRANT ENGINEERING, INC.
CONSULTING ENGINEERS
1900 BOWEN DRIVE, SUITE 200, BOCA RATON, FL 33433 • (407) 822-1271


LAKE COUNTY AREA
VC-TECH CENTER

EAST FL.

PARTIAL
FLOOR PLAN
ELECTRICAL

DATE: 01/08/97
BY: [Signature]
CHECKED: [Signature]
E23

NAME: c:\drawings\9669\dwg\9669A4-4.DWG DATE: JAN 05, 1997 TIME: 5:21 PM

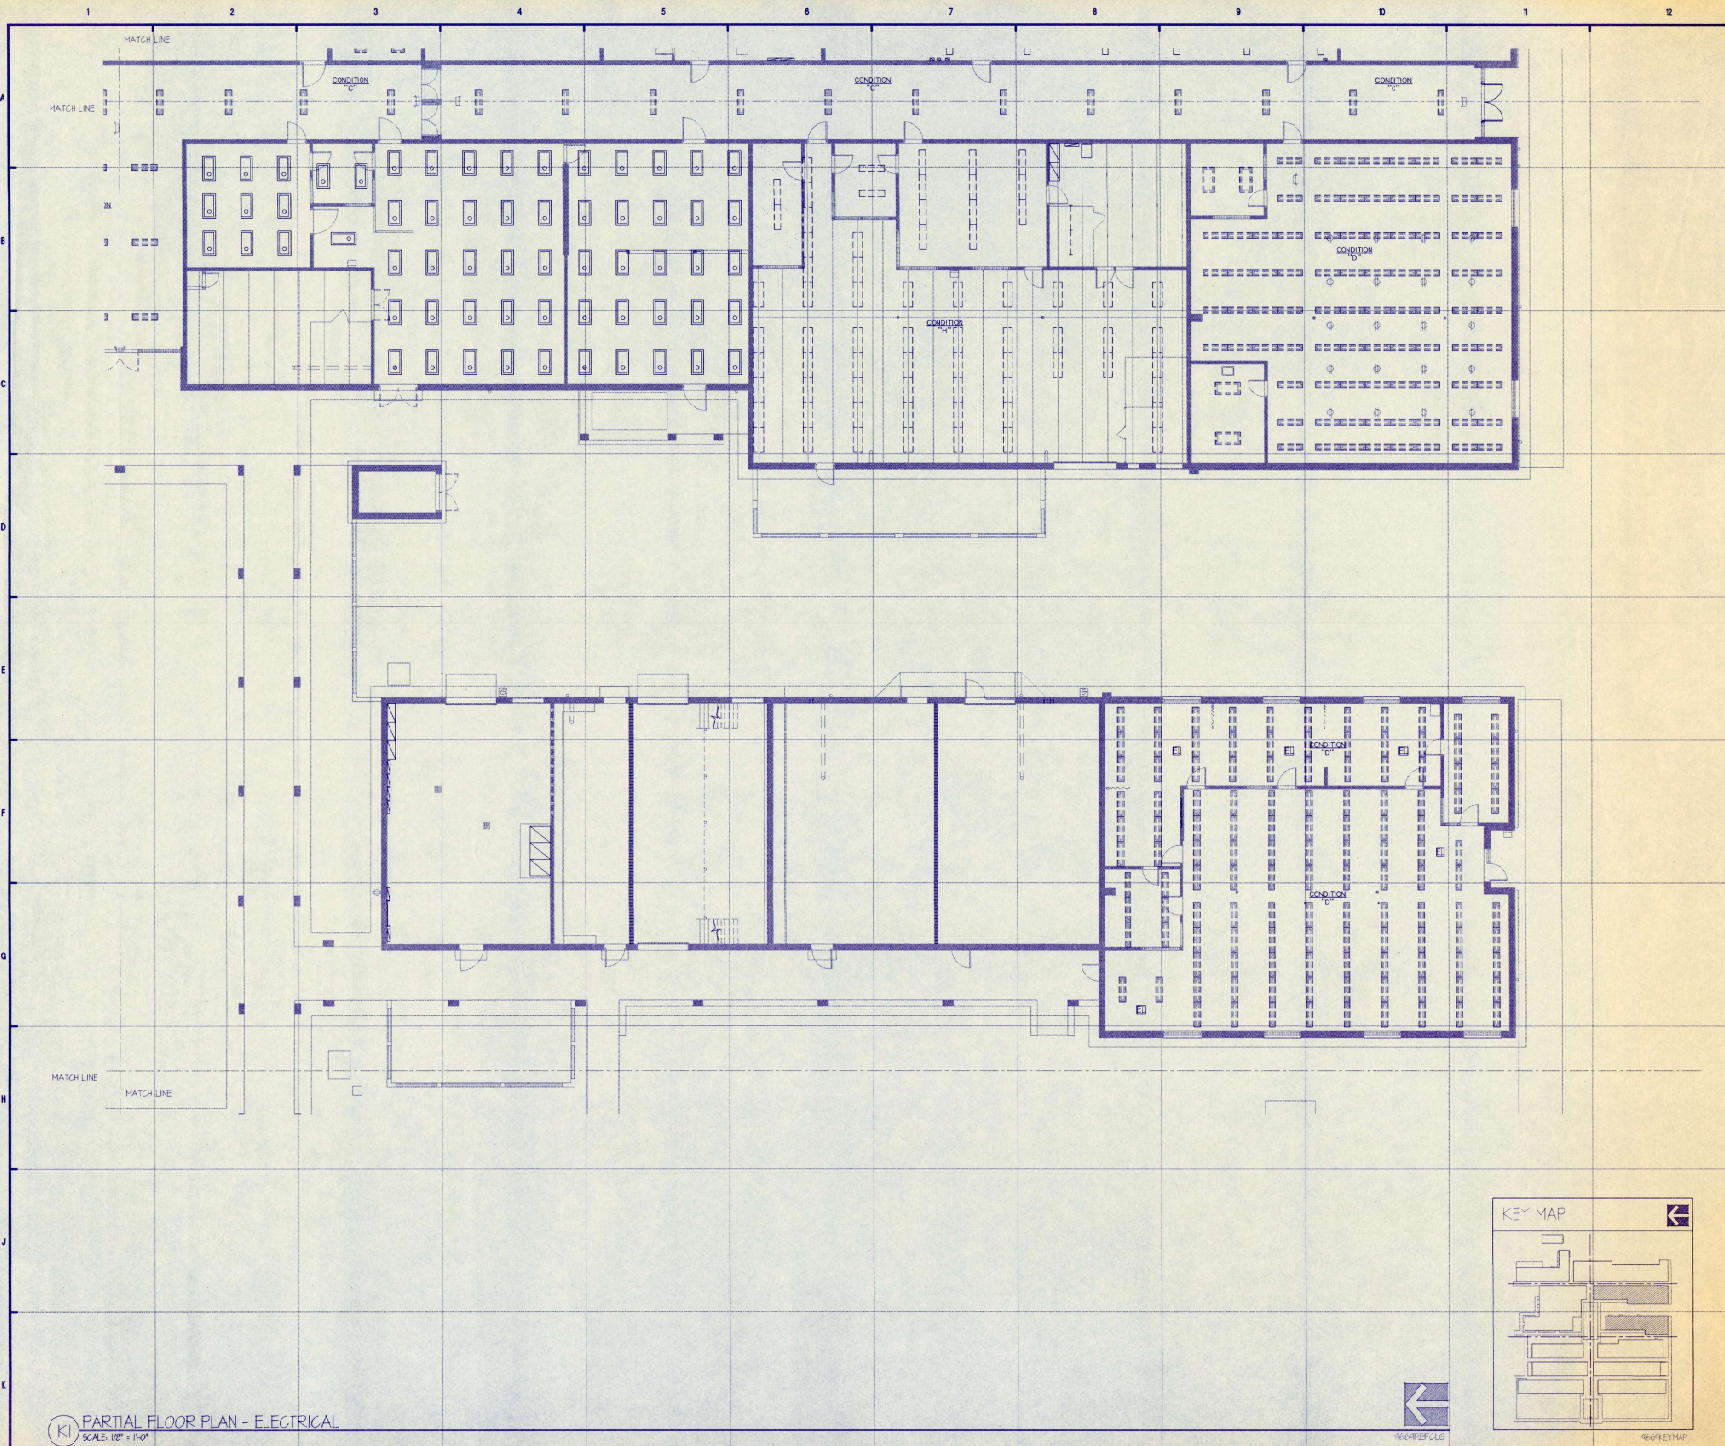

(K) PARTIAL FLOOR PLAN - ELECTRICAL
SCALE: 1/8" = 1'-0"

NOTES

PREVIOUS LIGHTING UPGRADES:
SEE WRITTEN SCOPE OF WORK
FOR DESCRIPTION AND
RECOMMENDATIONS REGARDING
PREVIOUS LIGHTING FIXTURE
UPGRADES.

PRELIMINARY
NOT FOR CONSTRUCTION


Rev	No	Date	Revised By

**BURKE, BALES & MILLS
ASSOCIATES, INC.**
ARCHITECTURE • PLANNING • INTERIOR DESIGN
141 N. W. 10th Ave., Suite 1100, Miami, FL 33135
(407) 352-4511 • FAX (407) 352-4511

GRANT ENGINEERING, INC.
CONSULTING ENGINEERS
3400 S.W. 10th Ave., Suite 100, Fort Lauderdale, FL 33309
(954) 341-1111 • FAX (954) 341-1111

LAKE COUNTY AREA	DATE
VO-TECH CENTER	2/90
BLVD, FL	15-87
PARTIAL FLOOR PLAN ELECTRICAL	9669
	A44

NAME: c:\drawings\966944\dwg DATE: JAN 08, 1997 TIME: 5:43 PM

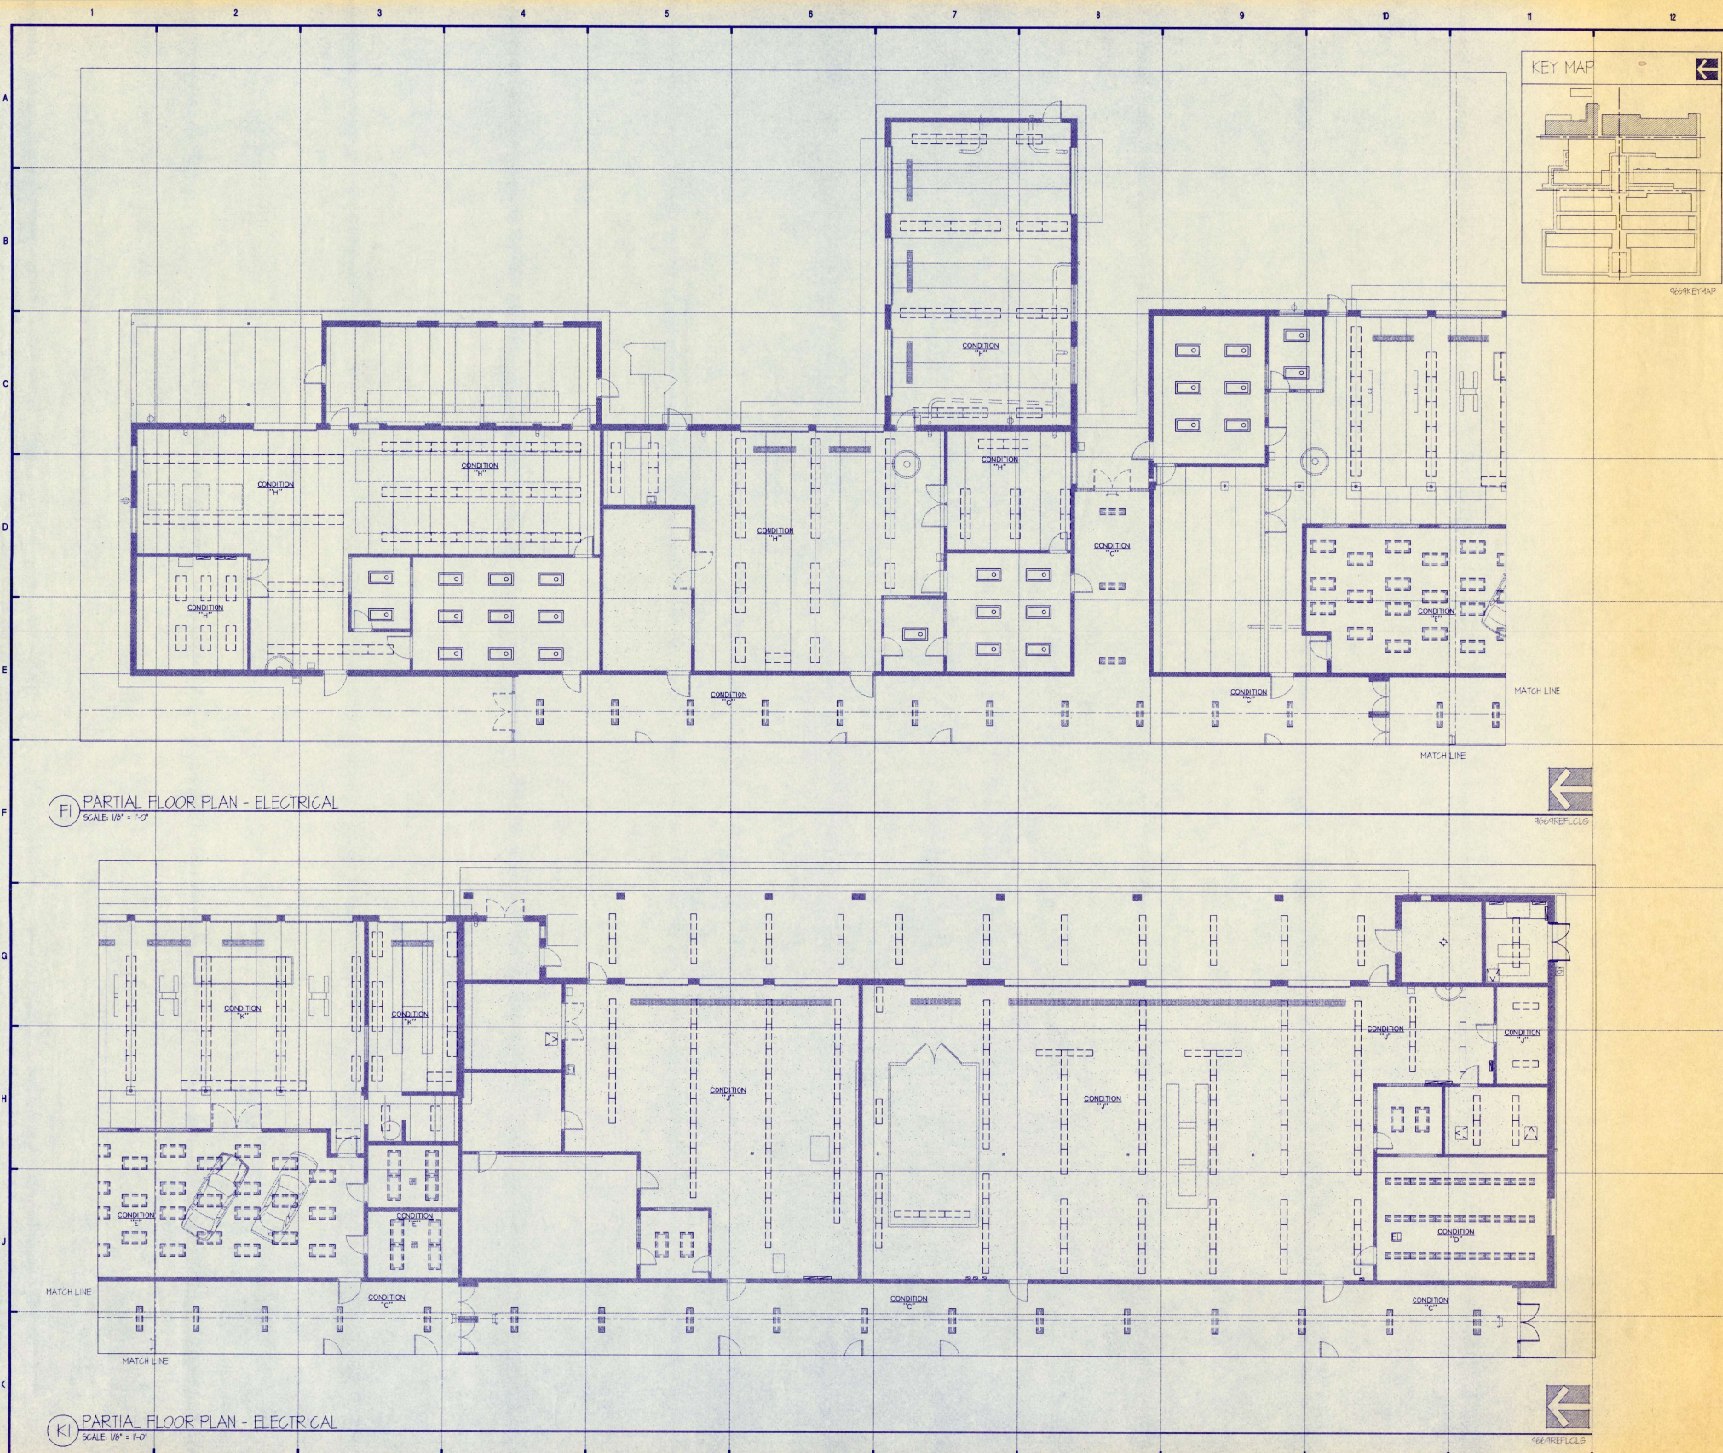

(F) PARTIAL FLOOR PLAN - ELECTRICAL
SCALE: 1/8" = 1'-0"

(K) PARTIAL FLOOR PLAN - ELECTRICAL
SCALE: 1/8" = 1'-0"

NOTES

PREVIOUS LIGHTING UPGRADES:
SEE WRITTEN SCOPE OF WORK
FOR DESCRIPTION AND
RECOMMENDATIONS REGARDING
PREVIOUS LIGHTING FIXTURE
UPGRADES.

PRELIMINARY
NOT FOR CONSTRUCTION

BURKE, EALES & MILLS
ASSOCIATES, INC.
ARCHITECTURE • PLANNING • INTERIOR DESIGN
311 N. WILSON AVE., SUITE 100 WILSON, IL 60151
(630) 654-0111 FAX (630) 654-0107

GRANT ENGINEERING, INC.
CONSULTING ENGINEERS
901 W. 10TH AVE., SUITE 200 CHICAGO, IL 60607
(312) 467-1100 FAX (312) 467-1101

LAKE COUNTY AREA	000
VO-TECH CENTER	200
BURTS FL.	10-07
PARTIAL FLOOR PLAN ELECTRICAL	000
	A45

MECHANICAL SYMBOL LEGEND

SYMBOL	DESCRIPTION	SYMBOL	DESCRIPTION	SYMBOL	DESCRIPTION
	SUPPLY AIR DIFFUSER, 4 WAY UNLESS OTHERWISE NOTED		DUCT MOUNTED SMOKE DETECTOR		CHECK VALVE
	RETURN AIR GRILLE		THERMOSTAT		RELIEF VALVE
	EXHAUST AIR GRILLE		HUMIDISTAT		SOLENOID VALVE
	SUPPLY AIR DIFFUSER WITH WARNINGS, 4 WAY UNLESS OTHERWISE NOTED		FIRESTAT		NEEDLE VALVE
	RETURN AIR GRILLE WITH WARNINGS		CARBON DIOXIDE SENSOR		PRESSURE REDUCING VALVE
	EXHAUST AIR GRILLE WITH WARNINGS		HVAC EQUIPMENT IDENTIFIER TAG		MOTOR OPERATED 2 WAY VALVE
	SUPPLY AIR SIDEWALL DIFFUSER		POINT OF CONNECTION TO EXISTING		MOTOR OPERATED 3 WAY VALVE
	RETURN AIR SIDEWALL GRILLE		REFERENCE NOTE NUMBER		STRAINER WITH BLOW DOWN
	EXHAUST FAN SHOWN ON FLOOR PLAN		UNDERCUT DOOR		AUTOMATIC AIR VENT
	EXHAUST FAN SHOWN ON ROOF		LOUVER DOOR		AIR VENT
	HVAC EQUIPMENT		SUPPLY AIR FLOW		SQUARE HEAD COCK
	DRYWELL		RETURN OR EXHAUST AIR FLOW		THERMOMETER
	UNIT HEATER (UH)		EXISTING TO REMAIN		TRAPS, STEAM (INDICATIVE TYPE)
	ELECTRIC DUCT HEATER		EXISTING TO BE REMOVED		SIGHT GLASS
	DUCT SIZE INDICAT ON, INSIDE DIMENSIONS (WIDTH X DEPTH)		CONDENSATE DRAIN PIPING		PIPE ANCHOR
	DUCT WITH INTERNAL LINING		REFRIGERANT PIPING		
	TEE WITH TURNING VANES		CHILLED WATER SUPPLY PIPING		
	TEE WITH OUTLET FITTING		CHILLED WATER RETURN PIPING		
	ROUND BRANCH DUCT CONICAL TAP		HOT WATER SUPPLY PIPING		
	RECTANGULAR BRANCH DUCT TAKEOFF WITH SIDE FITTING		HOT WATER RETURN PIPING		
	SPIN-IN		CONDENSER WATER SUPPLY PIPING		
	SPIN-IN WITH MANUAL DAMPER		CONDENSER WATER RETURN PIPING		
	TRANSITION, ECCENTRIC		LIQUID LINE SUCTION		
	TRANSITION, CONCENTRIC		HOT OIL		
	RISE (UP) OR DROP (DN) IN DUCT		HIGH PRESSURE STEAM		
	DUCTWORK TURNING UP		MEDIUM PRESSURE STEAM		
	DUCTWORK TURNING DOWN		LOW PRESSURE STEAM		
	FLEXIBLE CONNECTION		ELBOW TURNED UP		
	ACCESS DOOR		ELBOW TURNED DOWN		
	AIR FLOW STATION (AFS)		TEE, OUTLET UP		
	WETTED ELBOW		TEE, OUTLET DOWN		
	WETTED ELBOW WITH TURNING VANES		CONNECTION, TOP		
	RADIUS ELBOW		CONNECTION, BOTTOM		
	FLEXIBLE DUCT		UNION, SCREWED OR FLANGED		
	SUPPLY DUCT SECTION		CAP		
	RETURN DUCT SECTION		BALL VALVE		
	EXHAUST DUCT SECTION		BUTTERFLY VALVE		
	ROUND DUCT SECTION		GATE VALVE		
	BACKDRAFT DAMPER (BDD)		GATE VALVE, ANGLE		
	FIRE DAMPER (FD)		GLOBE VALVE		
	SMOKE DAMPER (SD)		GLOBE VALVE, ANGLE		
	FIRE / SMOKE DAMPER (FSD)		THREE WAY VALVE		
	MANUAL DAMPER (MD)		PLUG VALVE		
	MOTOR OPERATED DAMPER (MOD)				
	RADIATION DAMPER (RD)				

NOTE: THIS IS A STANDARD LIST OF SYMBOLS. SOME SYMBOLS SHOWN ON THIS LEGEND MAY NOT APPLY TO THE PROJECT.

PRELIMINARY
NOT FOR CONSTRUCTION


Rev	By	Date	Notes

BURKE, BALES & MILLS ASSOCIATES, INC.
ARCHITECTURE • PLANNING • INTERIOR DESIGN
241 N. Main Street, Suite 100, Orlando, FL 32801
(407) 838-4111 • FAX (407) 838-9070

BCA Brian Cumming & Associates, Inc.
1115 McIntosh Drive, Suite 100, Orlando, FL 32803
(407) 993-1899 • Fax (407) 993-1898 • Email bca@bca-inc.com

LAKE COUNTY AREA	DR. JRM
VC-TECH CENTER	DR. JRM
BURKE, FL	DR. BIC
SYMBOL LEGEND	DATE: 11/10/07
GENERAL NOTES	BY: BIC/BIC
MECHANICAL	MOO


NOTES

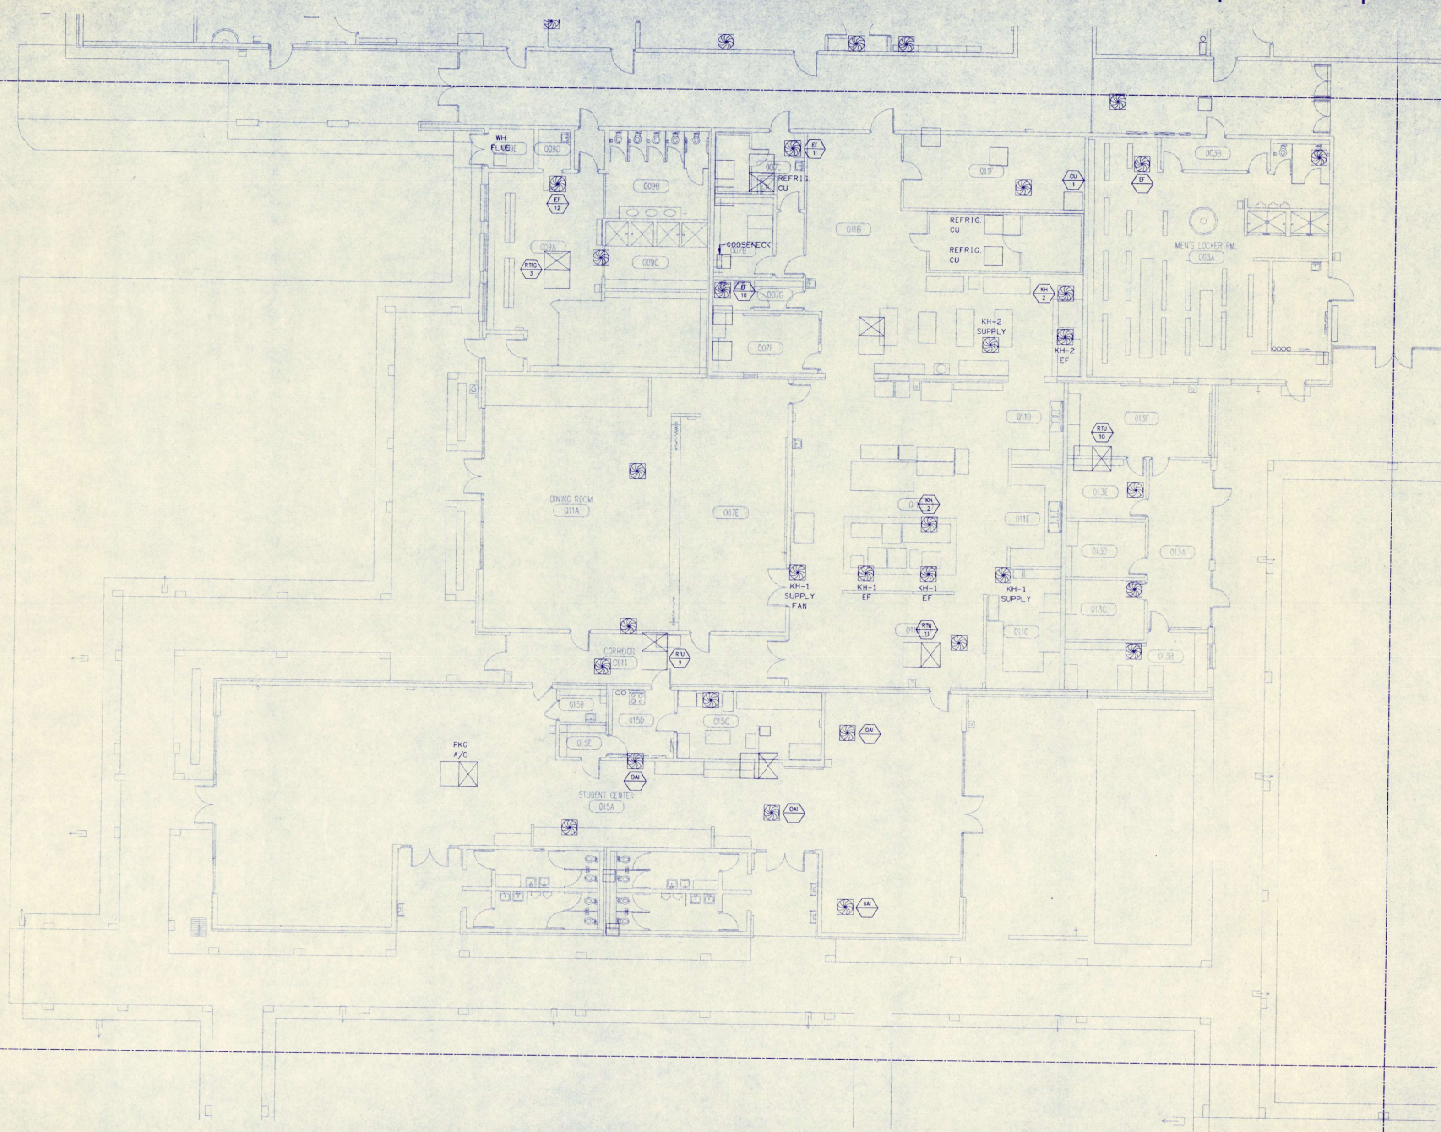

PRELIMINARY

NOT FOR CONSTRUCTION

NO.	DATE	REVISION
1		
2		
3		
4		
5		
6		
7		
8		
9		
10		

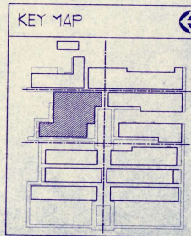


PARTIAL DEMOLITION PLAN - MECHANICAL
SCALE: 1/8" = 1'-0"

BURKE, BALES & MILLS ASSOCIATES, INC.
ARCHITECTURE - PLANNING - INTERIOR DESIGN
111 N. Main Street, Suite 100, Chicago, IL 60601
(312) 467-1111 FAX: (312) 467-1112

BCA Brian Curran & Associates, Inc.
111 N. Main Street, Suite 100, Chicago, IL 60601
(312) 467-1111 FAX: (312) 467-1112

LAKE COUNTY AREA	DATE
VO-TECH CENTER	1/1/00
CHICAGO, IL	1/1/00
PARTIAL DEMOLITION PLAN	1/1/00
MECHANICAL	1/1/00


THIS PLAN IS A PRELIMINARY DESIGN. IT IS NOT TO BE USED FOR CONSTRUCTION. THE CLIENT IS RESPONSIBLE FOR OBTAINING ALL NECESSARY PERMITS AND APPROVALS. THE ARCHITECT ASSUMES NO LIABILITY FOR ANY ERRORS OR OMISSIONS. THE ARCHITECT'S WORK IS LIMITED TO THE DESIGN OF THE BUILDING AND ITS MECHANICAL SYSTEMS. THE ARCHITECT DOES NOT PROVIDE ANY SERVICES FOR THE DESIGN OF THE LAND OR THE DESIGN OF THE STRUCTURE. THE ARCHITECT'S WORK IS LIMITED TO THE DESIGN OF THE BUILDING AND ITS MECHANICAL SYSTEMS. THE ARCHITECT DOES NOT PROVIDE ANY SERVICES FOR THE DESIGN OF THE LAND OR THE DESIGN OF THE STRUCTURE.

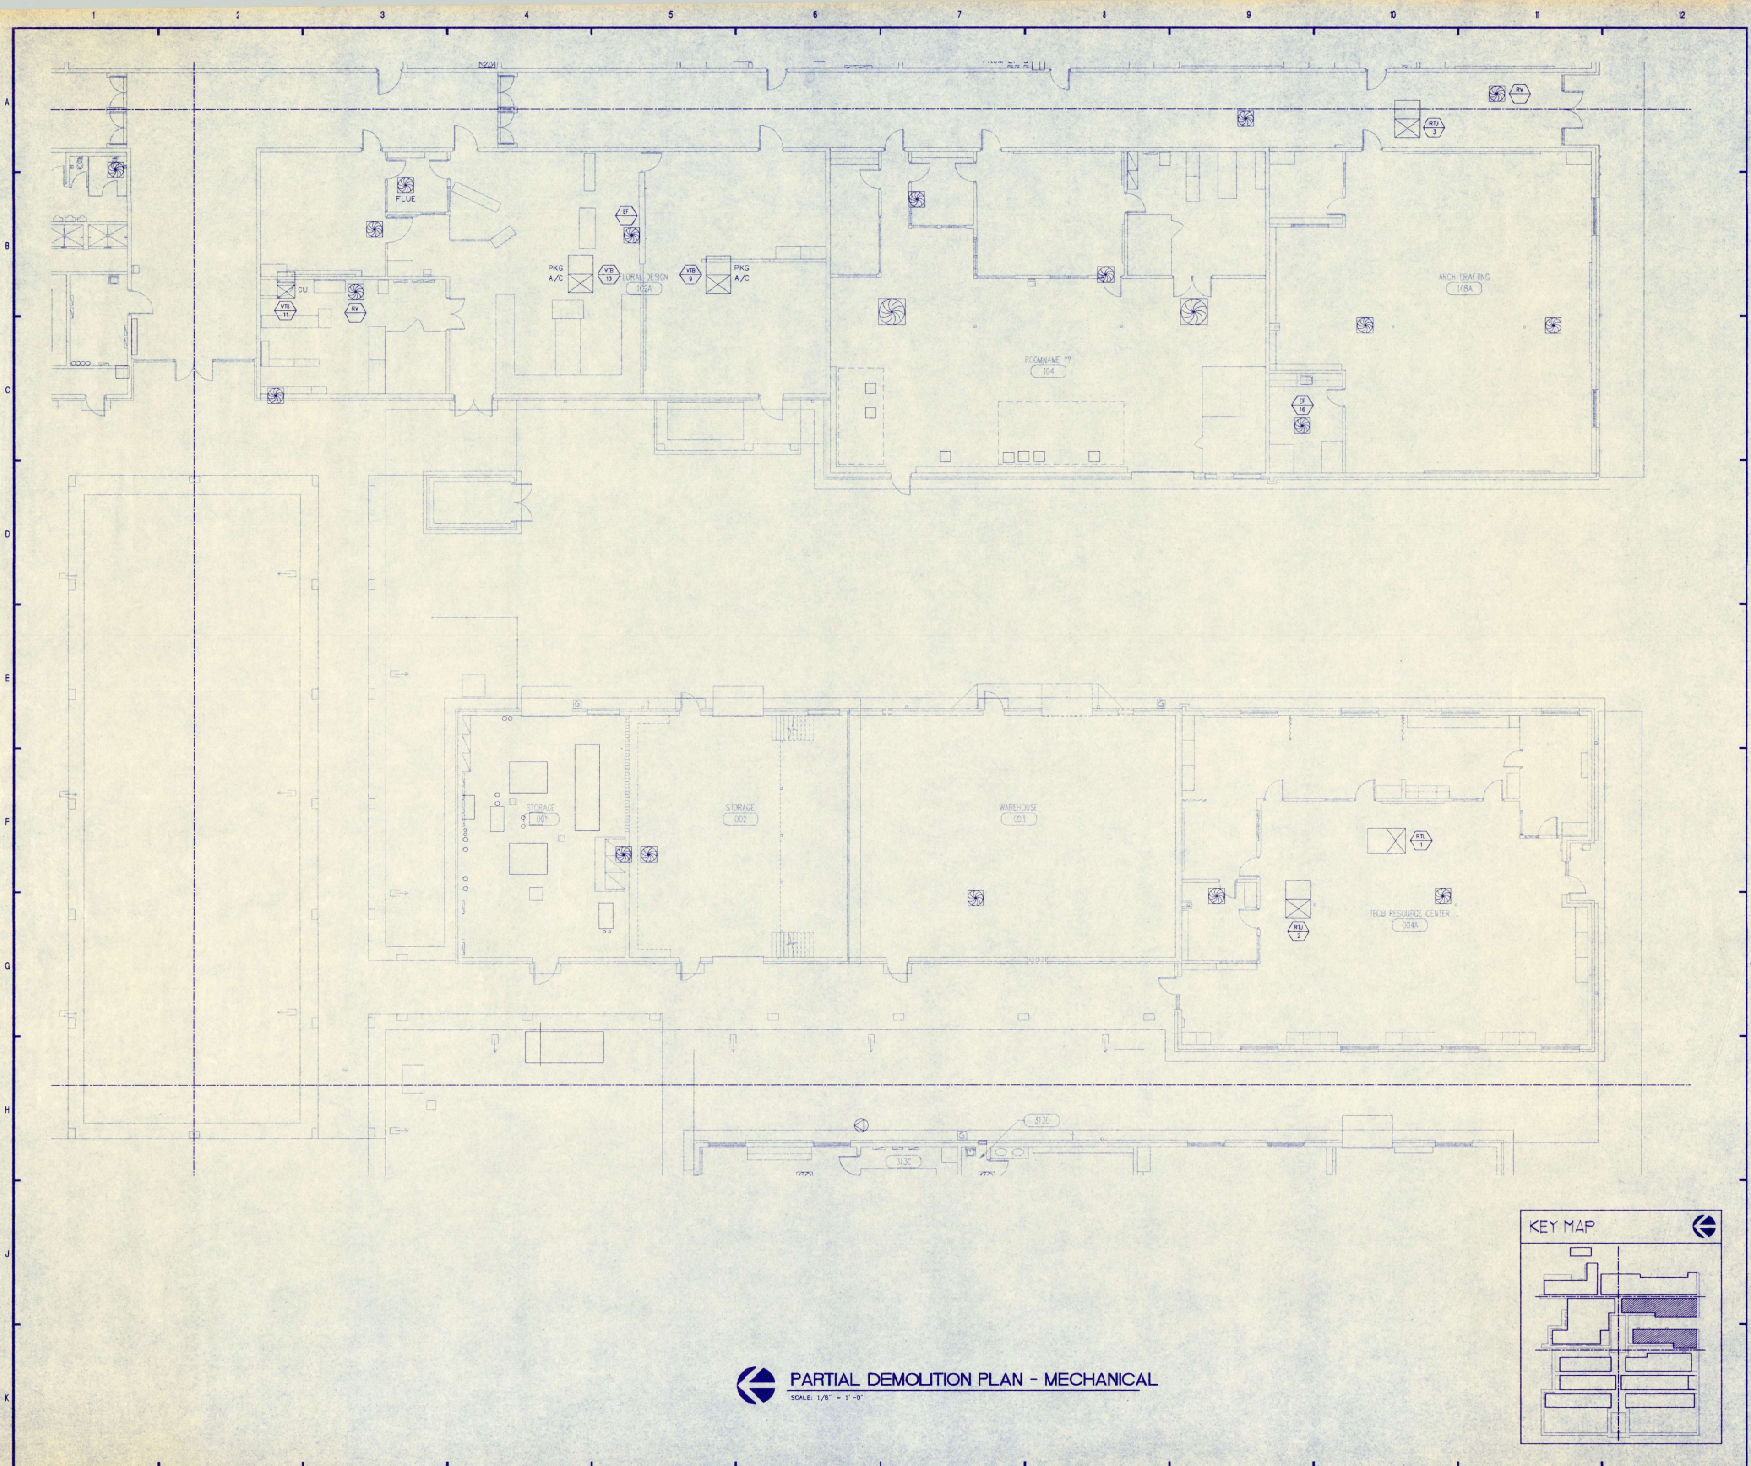

PARTIAL DEMOLITION PLAN - MECHANICAL

SCALE: 1/8" = 1'-0"

KEY MAP

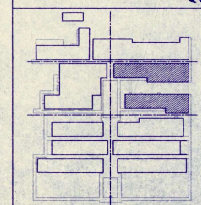

NOTES

PRELIMINARY
FOR CONSTRUCTION

NO.	DATE	REVISION
1		
2		
3		
4		
5		
6		
7		
8		
9		
10		

BURKE, BALES & MILLS ASSOCIATES, INC.
ARCHITECTURE • PLANNING • INTERIOR DESIGN
311 S. Main Street, Suite 100, Madison, WI 53703
(608) 441-1111 • Fax (608) 441-1112

BCA Brian Cumming & Associates, Inc.
385 Midway Road • Suite 100 • Madison, WI 53703
(608) 261-1111 • Fax (608) 261-1112

LAKE COUNTY AREA
VO-TECH CENTER

ELSTON, IL

PARTIAL
DEMOLITION PLAN
MECHANICAL

DATE: 08/14/00
BY: BBA
CHECKED: BBA
DATE: 08/14/00
BY: BBA

PRELIMINARY
NOT FOR CONSTRUCTION


NOT FOR CONSTRUCTION

BURKE, BALES & MILLS
ASSOCIATES, INC
ARCHITECTURE • PLANNING • INTERIOR DESIGN
341 N. Mainland Ave., Suite 100 Westland, MI 48091
(407) 621-4511 FAX (407) 636-9070

BCA Brian Cumming & Associates, Inc.
3152 McDuffy Place • Suite 109 • Braintree, IL 60013
(407) 861-1288 • Fax: (407) 861-1445 • Email: bca@bca-inc.com

LAKE COUNTY AREA VO-TECH CENTER BURTIS FL		Co.	JWR
		Cn.	JWR
		ESC	ESC
		VT/RT	VT/RT
		PROJ	0609/ECAG80C3
PARTIAL DEMOLITION PLAN MECHANICAL		M15	


M15

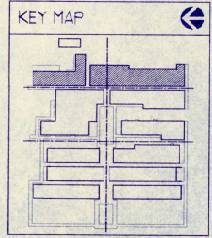

KEY MAP

 **PARTIAL DEMOLITION PLAN - MECHANICAL**
SCALE: 1/8" = 1'-0"


PARTIAL DEMOLITION PLAN - MECHANICAL
 SCALE: 1/8" = 1'-0"

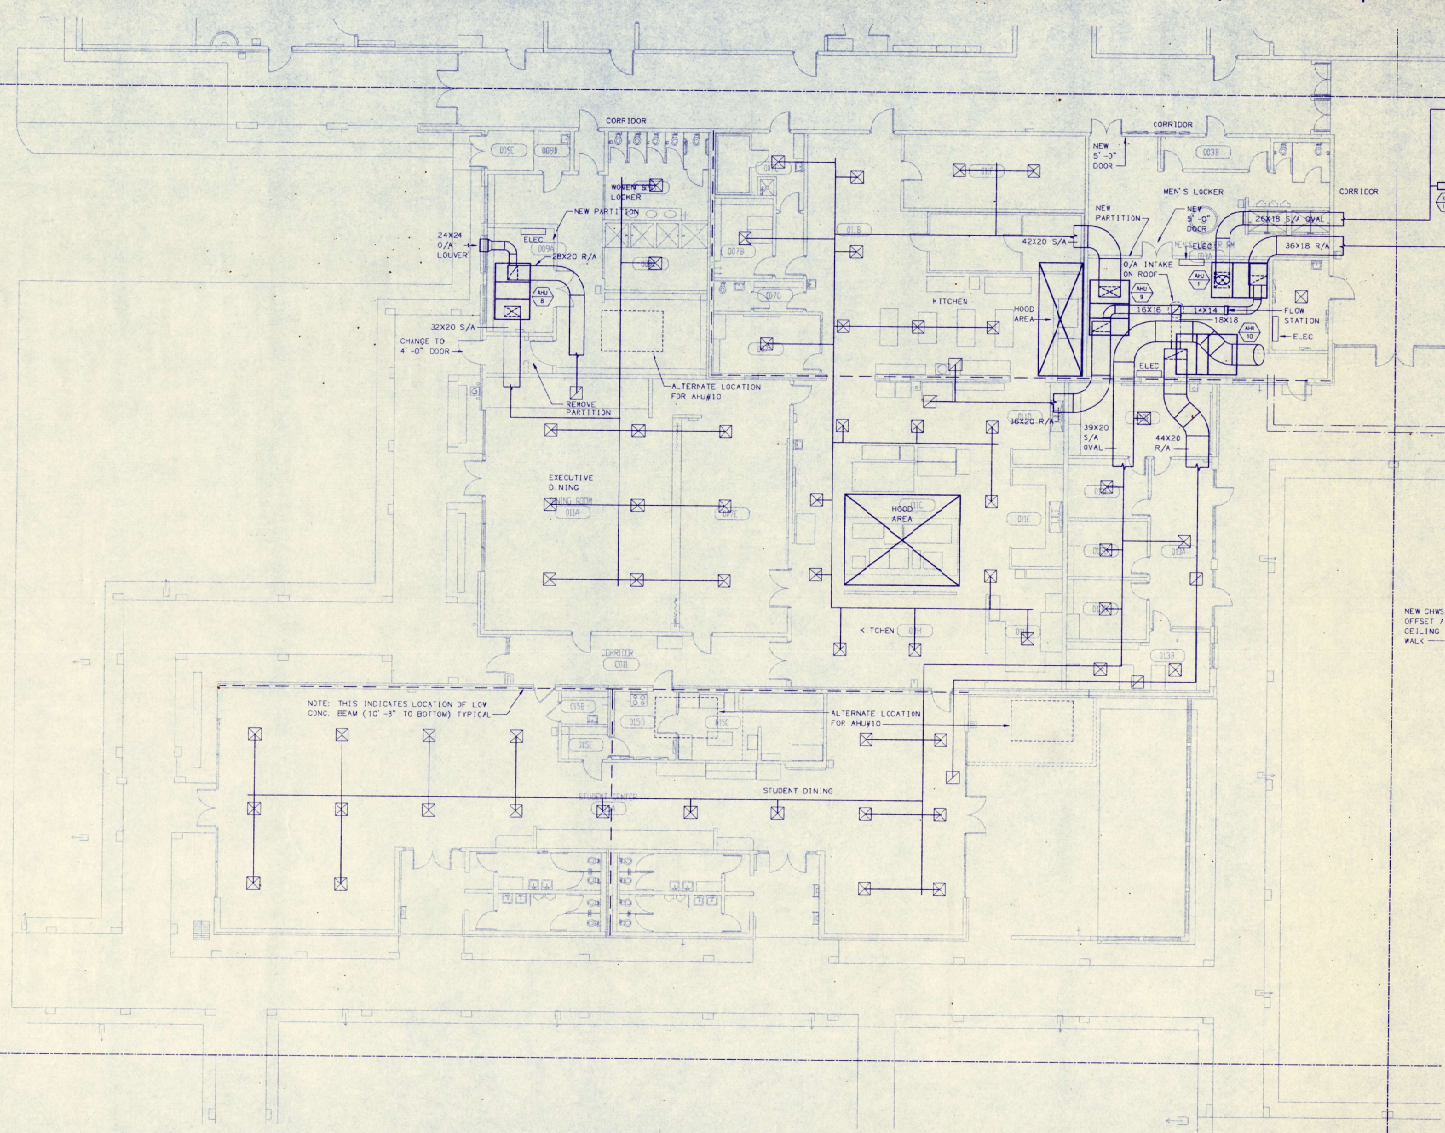


NEW CHWS
OFFSET /
CEILING
WALLS

NOTE: THIS INDICATES LOCATION OF LOW
COND. BEAM (10'-0" TO BOTTOM) TYPICAL



PARTIAL FLOOR PLAN - MECHANICAL

SCALE: 1/8" = 1'-0"

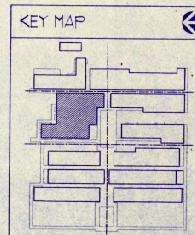

PRELIMINARY
NOT FOR CONSTRUCTION


NO.	DATE	REVISION

BURKE, BALES & MILLS ASSOCIATES, INC.
ARCHITECTURE - PLANNING - INTERIOR DESIGN
241 N. Main Street, Suite 100, Madison, WI 53701
(608) 261-1111 • FAX (608) 261-1112

BCA Brian Cunniff & Associates, Inc.
1415 McFarland Avenue, Suite 100, Madison, WI 53704
(608) 261-2881 • FAX (608) 261-2882

LAKE COUNTY AREA	JB
VO-TECH CENTER	JB
DATE: 11/11/01	BC
PARTIAL FLOOR PLAN	YCB
MECHANICAL	BC/M/SCANDON
	M23

NOTES

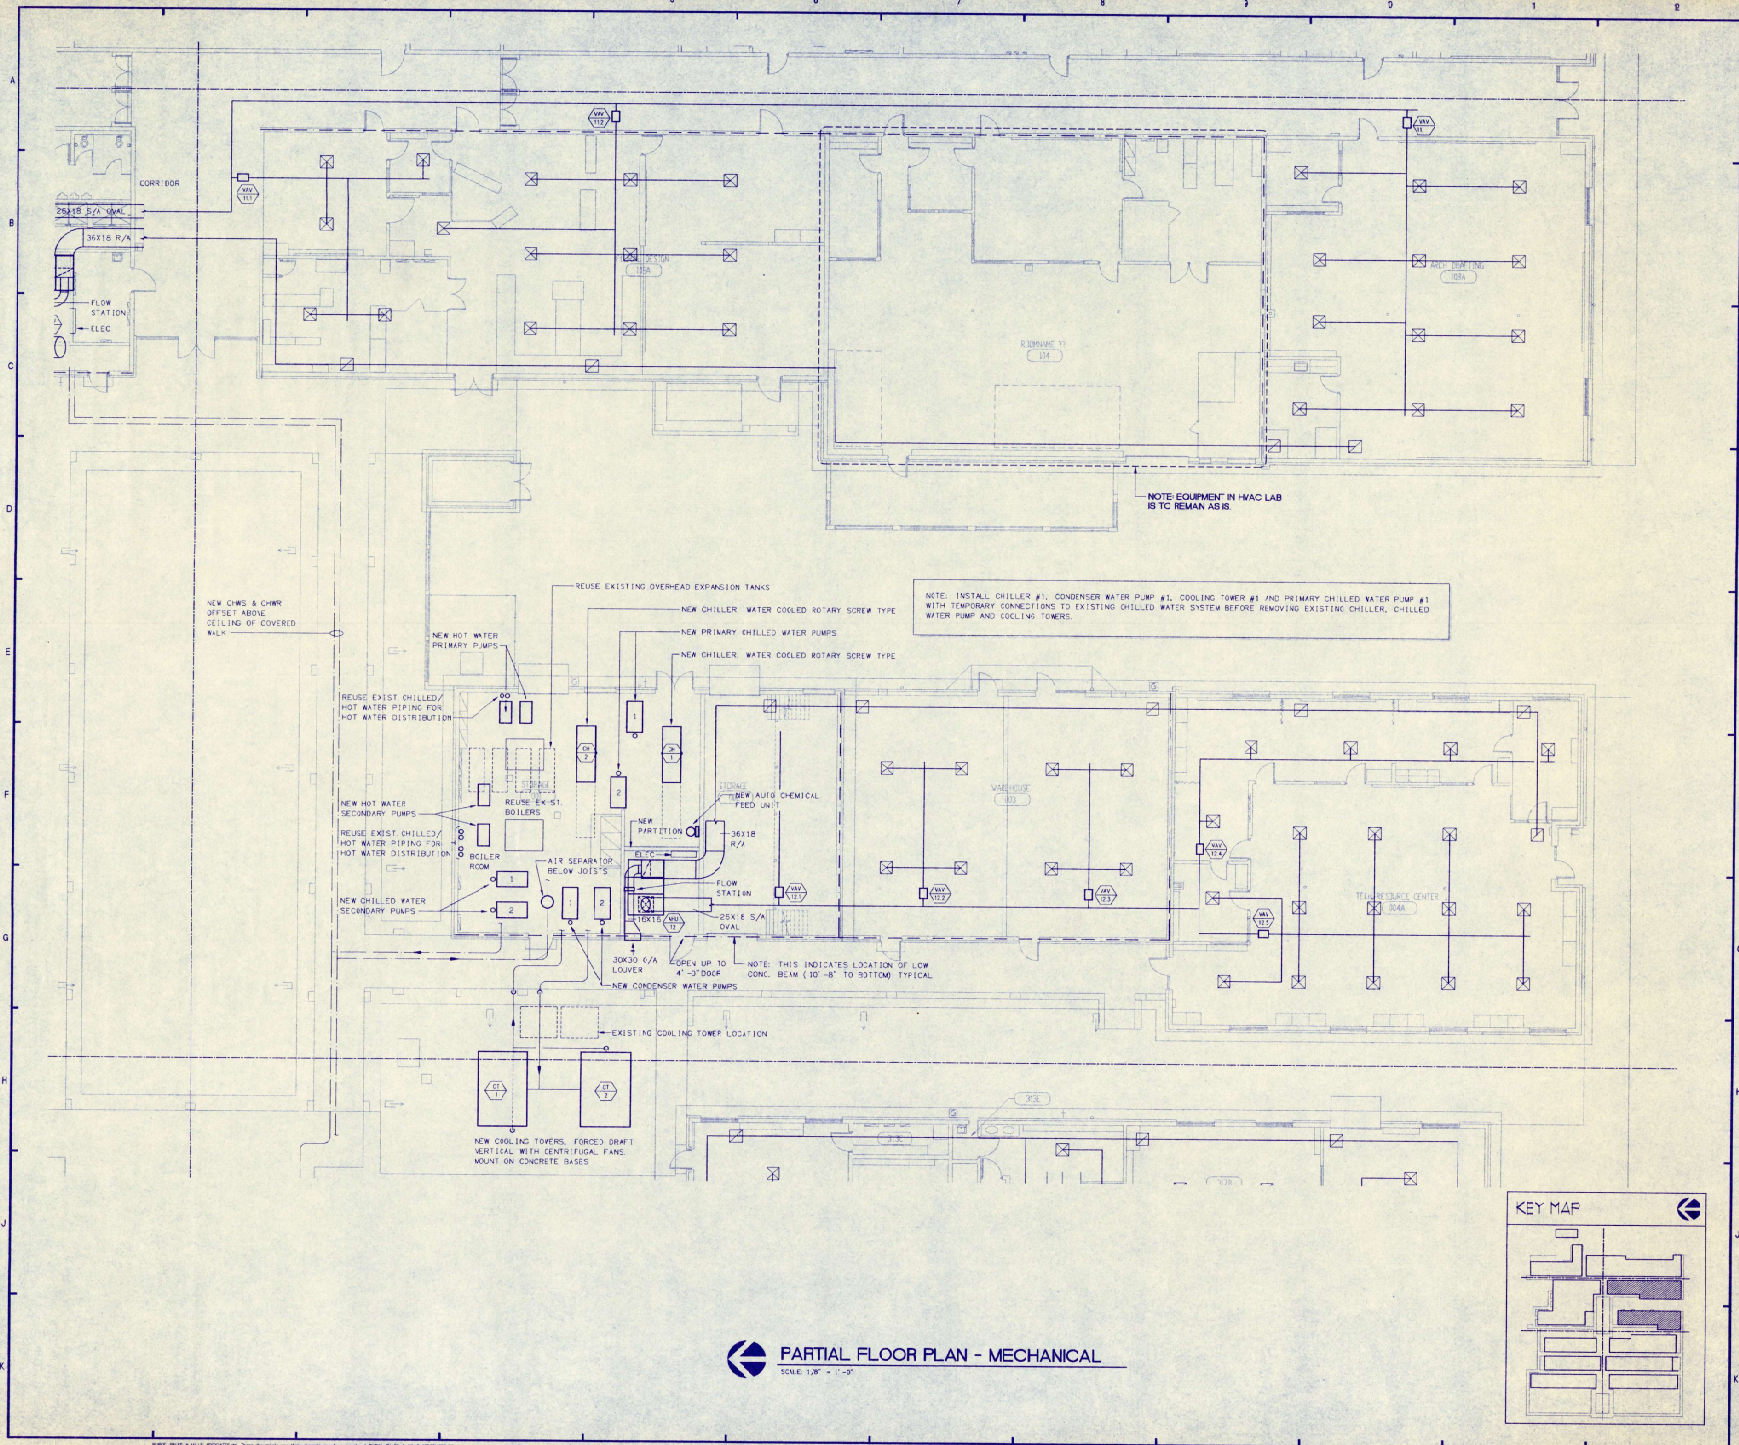

PRELIMINARY
NOT FOR CONSTRUCTION

BURKE, BALES & MILLS ASSOCIATES, INC.
ARCHITECTURE - PLANNING - INTERIOR DESIGN
24 N. Oakland Ave., Suite 130, Maitland, FL 32751
(407) 895-0311 • FAX (407) 895-0370

BCA **Drum Canning & Associates, Inc.**
1455 Kennedy Pkwy., Suite 1021, Orlando, FL 32803
(407) 997-1300 • FAX (407) 997-1440 • WWW.DCA360.COM

LAKE COUNTY AREA
VO-TECH CENTER
BUREAU PL.

PARTIAL FLOOR PLAN
MECHANICAL

M24

NOTES

A

B

C

D

E

F

G

H

J

K

PRELIMINARY

NOT FOR CONSTRUCTION

REV.	DATE	REVISION
1		
2		
3		
100		



**BURKE, BALES & MILLS
ASSOCIATES, INC.**
ARCHITECTURE PLANNING INTERIOR DESIGN
341 N. Macdonald Ave., Suite 200 Macdonald, FL 32711
(407) 488-4411 FAX (407) 428-8870



Brian Cunningham & Associates, Inc.
1115 Midway Plaza Suite 100 • Orlando, FL 32815
(407) 390-1200 • FAX (407) 390-7440 • Email: bca@bca-inc.com

**LAKE COUNTY AREA
VO-TECH CENTER**

BURKE, FL

**PARTIAL
FLOOR PLAN
MECHANICAL**

by: **JMB**


ch: **JMB**

rev: **ENC**

date: **12/01/01**

rev: **DRWG REVISION**

V2.5

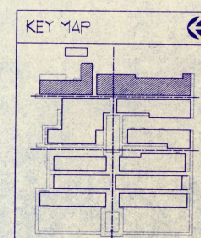

H				
				
				
				
				
				
				
				
				
				
Rev.	No.	Date	Issue History	

BCA Brian Cumming & Associates, Inc.
1155 McNary Place - Suite 100 • Orem, UT 84058
801/226-1280 • Fax: 801/226-1445 • Email: bca@comcast.net

LAKE COUNTY AREA VO-TECH CENTER	
BATES, F.	
PARTIAL FLOOR PLAN MECHANICAL	DR. JMR D. JMR EBC DATE 11/1/97 PLOT 0096/ 3C490028 W25

NOTE: BATES & BATES ASSOCIATES, INC. These documents and their contents are the property of BATES, BATES & BATES ASSOCIATES, INC. and are loaned only for the specific project stated in these documents. Any reproduction or unauthorized use without the expressed written consent of BATES, BATES & BATES ASSOCIATES, INC. is prohibited.

