
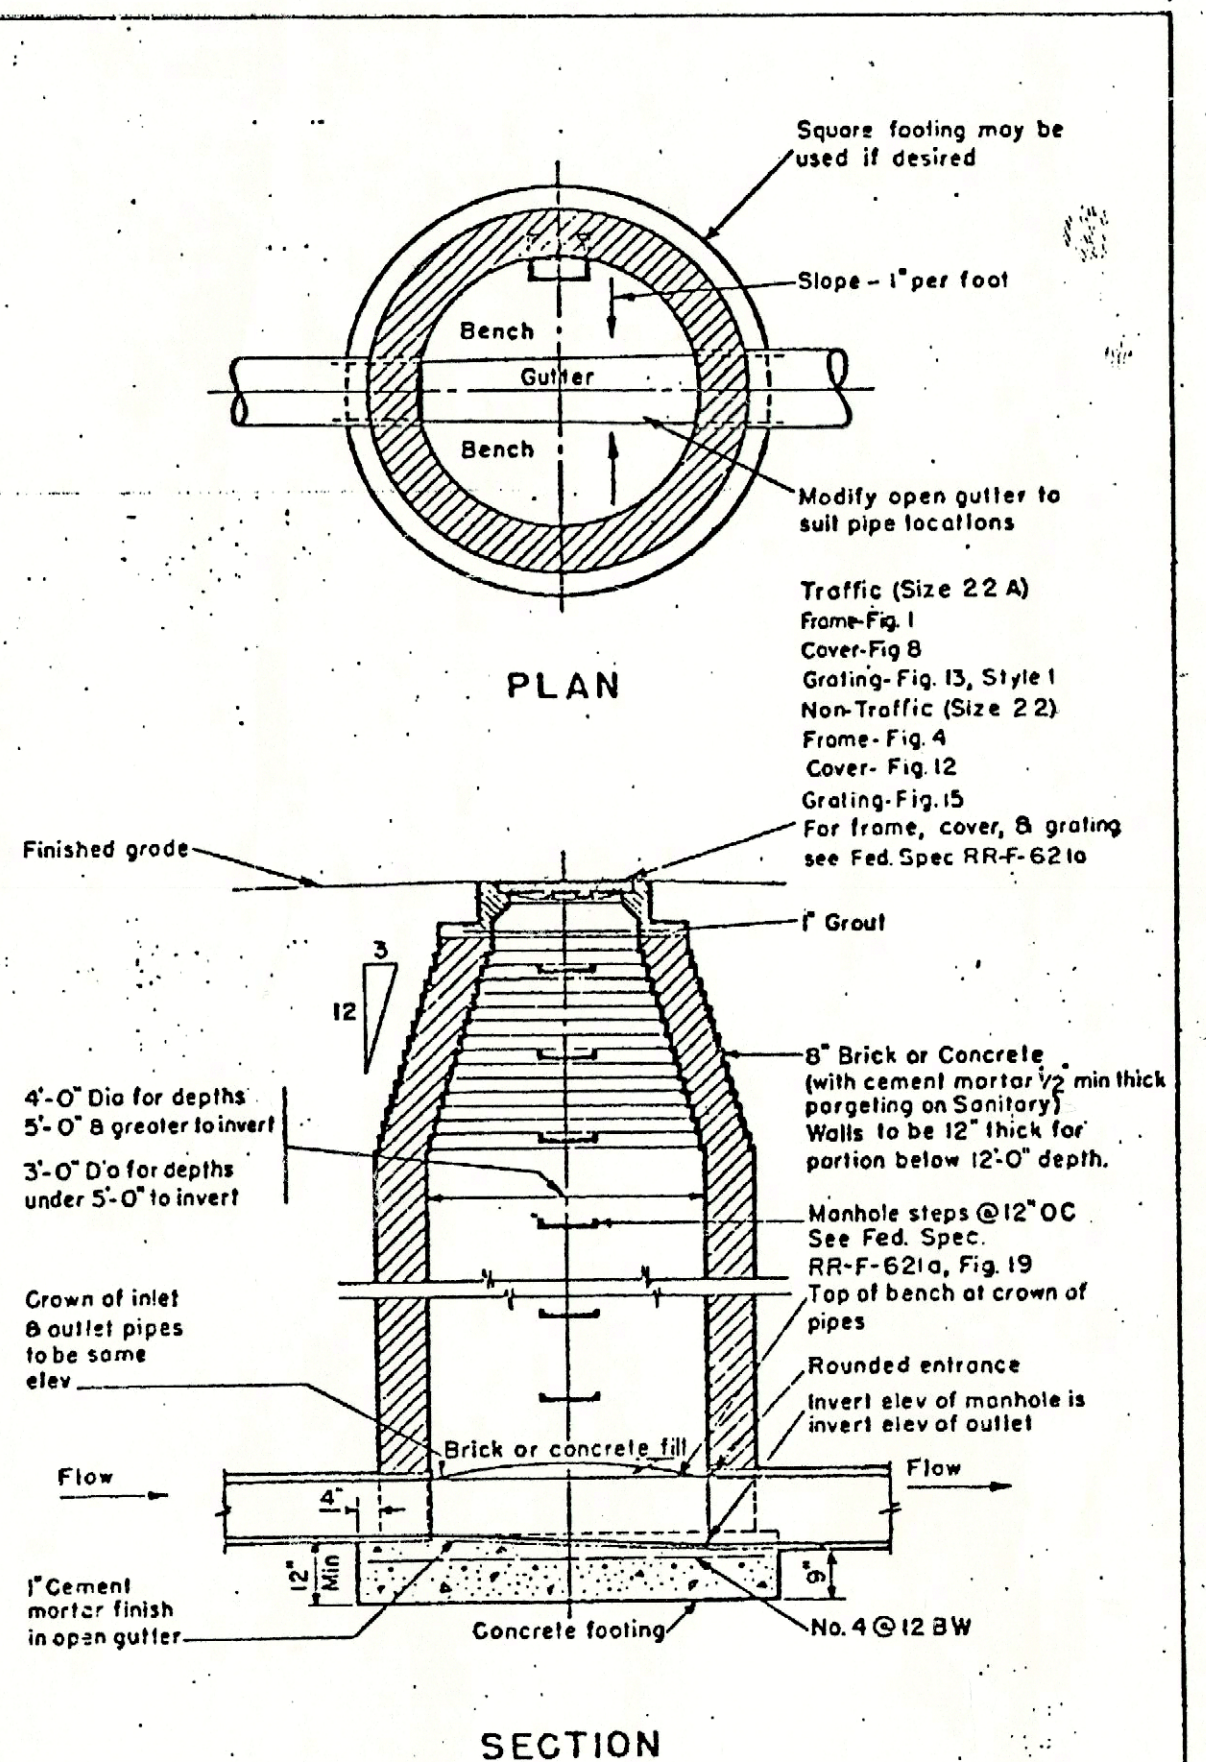




MARK	DESCRIPTION	WASTE	H.W.	C.W.	SELECTION
U-1	URINAL: VITREOUS CHINA, WALL HUNG SIPHON JET W/WALL HANGERS, EXPOSED FLUSH VALVE.	2"	---	1"	ELJER 161-1160 SLOAN ROYAL 180-VV
U-2	URINAL: SAME AS U-1, EXCEPT MOUNT 19" FROM FLOOR TO TOP OF LIP.	2"	---	1"	SAME AS U-1
WC-1	WATER CLOSET: WALL HUNG, SIPHON JET, ELONGATED BOWL, CONCEALED CHAIR CARRIER, EXPOSED FLUSH VALVE, SOLID PLASTIC SEAT LESS COVER.	4"	---	1 1/4"	ELJER 111-1405, SLOAN ROYAL 110-3 BENEKE 523SCHHP
WC-2	WATER CLOSET: SAME AS WC-1 EXCEPT MOUNT 20" FROM FLOOR TO TOP OF SEAT.	4"	---	1 1/4"	SAME AS WC-1
SH-1	SHOWER: FLOOR UNDER ANOTHER SECTION OF CONTRACT. ANTI-SCALD BALANCED PRESSURE, SINGLE LEVER SHOWER VALVE, FLOW REGULATOR, CHECK STOPS, VANDAL-RESISTANT. SET ADJUSTABLE TEMPERATURE LIMIT STOP @ MAXIMUM 105°F. SHOWER DRAIN W/ CHROME PLATED STRAINER.	2"	1/2"	1/2"	SPEAKMAN S-1415-M-AF-IS-VR JOSAM 3000
SH-2	SHOWER: HANDICAP - FLOOR UNDER ANOTHER SECTION OF CONTRACT. ANTI-SCALD BALANCED PRESSURE, SINGLE LEVER SHOWER VALVE, SET ADJUSTABLE TEMPERATURE LIMIT TO 105°F. HAND SHOWER W/69" HOSE & SLIDE BAR. SHOWER DRAIN W/CHROME PLATED STRAINER.	2"	1/2"	1/2"	SPEAKMAN S-1420-IS-M-VR, VS-115, VS-124, VS-100, VS-149-69" JOSAM 3000
WF-1	WASH FOUNTAIN: 36" CIRCULAR PRECAST TERRAZZO COMPLETE W/METAL SOAP DISPENSER, S.S. SHROUD & ALL REQUIRED CONTROLS. COLD WATER ONLY.	2"	---	1"	BRADLEY BFC-SH. PRECAST TERRAZZO 36" CIRCULAR- <i>PROVIDE CONTROLS FOR HANDICAP OPERATION.</i>
WF-2	WASH FOUNTAIN: 54" SEMI-CIRCULAR PRECAST TERRAZZO COMPLETE W/METAL SOAP DISPENSER & ALL REQUIRED CONTROLS. COLD WATER ONLY.	2"	---	1"	BRADLEY CFC PRECAST TERRAZZO 54" SEMI-CIRCULAR- <i>PROVIDE CONTROLS FOR HANDICAP OPERATION.</i>
S-1	SINK: COUNTERTOP - SELF RIM, ACID RESISTING ENAMELED CAST IRON, 25" X 22", DECK FAUCET (COLD WATER TO BOTH SIDES), CRUMB CUP STRAINER, CAST BRASS "P" TRAP, SUPPLIES W/STOP.	1 1/2"	---	1/2"	ELJER 212-1083, 715-1060, 803-0580, 804-1190
S-2	SINK: COUNTERTOP - SELF RIM, ACID RESISTING ENAMELED CAST IRON, 33" X 22", DECK FAUCET (COLD WATER TO BOTH SIDES), CRUMB CUP STRAINERS CAST BRASS "P" TRAP, SUPPLIES W/STOP.	1 1/2"	---	1/2"	ELJER 212-1088, 715-1060, 804-0580, 804-1190
SS	SERVICE SINK: ACID RESISTING ENAMELED CAST IRON, 24" X 20", FAUCET W/VACUUM BREAKER, TRAP STANDARD, S.S. RIM GUARD.	3"	1/2"	1/2"	ELJER 242-0135, 749-1200, 804-1060, 805-0190
S-3	SINK: COUNTERTOP - SELF RIM, ACID RESISTING ENAMELED CAST IRON, 25" X 22", DECK FAUCET W/WRIST BLADES & GOOSENECK, CRUMB CUP STRAINER, CAST BRASS "P" TRAP, SUPPLIES W/STOPS.	1 1/2"	---	1/2"	ELJER 212-1083, 559-1270, 803-0580, 804-1190
L-1	LAVATORY: COUNTER, OVAL, ENAMELED CAST IRON, SELF-RIMMING, 20" X 17", SINGLE METERING FAUCET, CHROME COCK HOLE COVERS, GRID STRAINER, SUPPLY W/SCREWDRIIVER STOP, CAST BRASS "P" TRAP.	1 1/2"	---	1/2"	ELJER 052-0274, SPEAKMAN S-4121, S-3440 ELJER 804-1180.
L-2	LAVATORY: WALL HUNG, ENAMELED CAST IRON W/WALL HANGER, 20" X 18", SINGLE METERING FAUCET, CHROME COCK HOLE COVERS, GRID STRAINER, SUPPLY W/SCREWDRIIVER STOP, CAST BRASS "P" TRAP.	1 1/2"	---	1/2"	ELJER 052-0174 SPEAKMAN S-4121AF, S-3440 ELJER 804-1180
L-3	LAVATORY: WALL HUNG, ENAMELED CAST IRON W/WALL HANGER, 20" X 18", COMBINATION SELF-CLOSING FAUCET, GRID STRAINER, SUPPLIES W/SCREWDRIIVER STOPS, CAST BRASS "P" TRAP.	1 1/2"	1/2"	1/2"	ELJER 052-0188 SPEAKMAN S-4121AF ELJER 804-1180
L-4	LAVATORY: WALL HUNG, ENAMELED CAST IRON W/WALL HANGER, 20" X 18", FAUCET W/WRIST BLADE HANDLES GRID STRAINER, SUPPLIES W/SCREWDRIIVER STOPS, CAST BRASS "P" TRAP.	1 1/2"	1/2"	1/2"	ELJER 052-0188 SPEAKMAN S-3044-FLO ELJER 804-1180
EW	ELECTRIC WATER COOLER: WALL MTD., WHEEL CHAIR, S.S. TOP-BACK SPLASH CABINET, 7 GPH @500 W/800 INLET & 900 ROOM TEMP. "P" TRAP W/C.O., ANGLE STOP, SEALED REFRIGERANT SYSTEM, 1/8 HP 115/60 /10. TOP 33" ABOVE FLOOR.	1 1/2"	---	1/2"	OASIS ODP 7MM-D
DF	DRINKING FOUNTAIN: VITREOUS CHINA W/INTEGRAL STRAINER & WALL HANGER, SELF CLOSING VALVE, VANDALPROOF BUBBLER, SUPPLY W/STOP, CAST BRASS "P" TRAP.	1 1/2"	---	1/2"	ELJER 191-0500
RD	ROOF DRAIN: CAST IRON WITH DECK CLAMP, DRAIN RECEIVER, CAST IRON FRAME, SIZE INDICATED, INHIBITS ALL PIPE IN ATTIC SPACE W/1/2" AIRWATER				JOSAM 21000

SPACE IDENTIFICATION

- 1 INDIVIDUALIZED MANPOWER TRAINING
- 2 WORD PROCESSING
- 2a DRAFTING
- 3 EMERGENCY MED. TECH. & PARAMED
- 3a SMALL BUSINESS (DIST. ED.)
- 4 ROOF SERVICE
- 5 LANDSCAPE OPERATIONS
- 6 AUTOMOTIVE BODY REPAIR
- 7 GASOLINE ENGINE MECHANICS
- 8 CURRICULUM JOB PLACEMENT
- 9 BLDG. "C" SUPPORT FACILITIES
- 10 BUILDING "B" STORAGE AREA
- 11 BUILDING "B" SUPPORT FACILITIES
- 12 PAVING & DRIVEWAYS
- 13 COVERED WALKWAYS

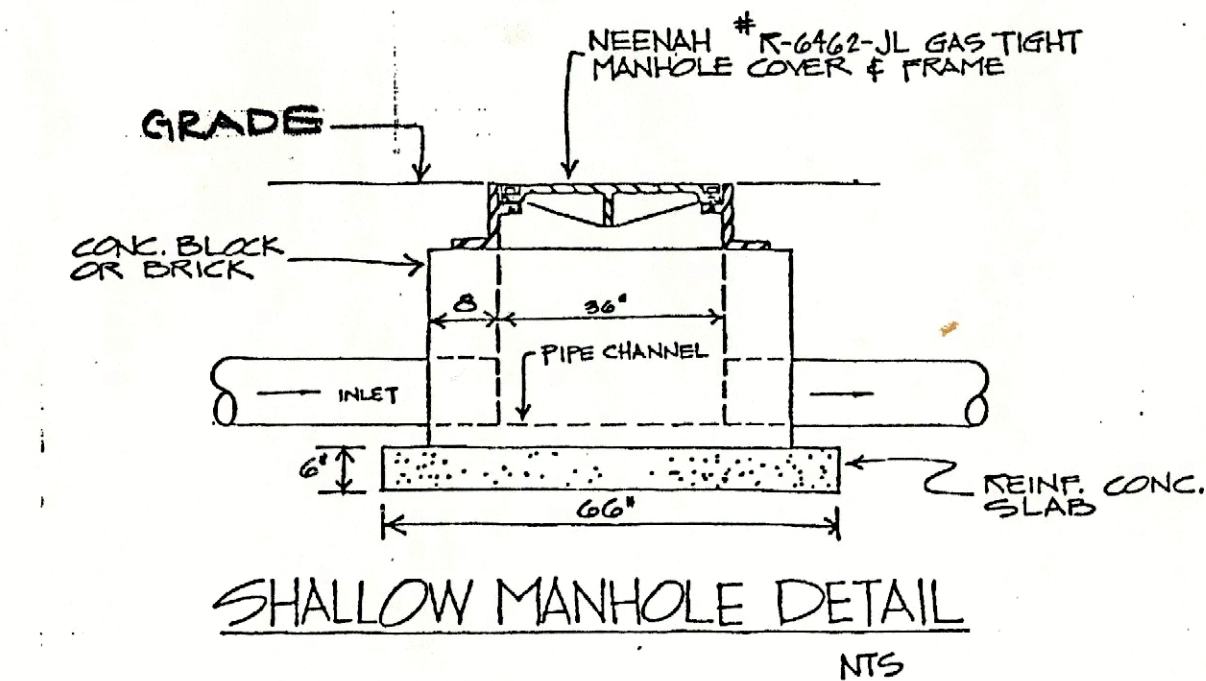

ST	DESCRIPTION
VP	VENT PIPE
CW	COLD WATER
HW	HOT WATER
HWC	HOT WATER CIRCULATING
G	GAS PIPE
A	AIR PIPE
FD	FLOOR DRAIN
ID	INDIRECT DRAIN
CO	CLEAN OUT
MH	MAN HOLE
	CONNECT TO EXISTING
VTR	VENT THRU ROOF
HB	HOSE BIBB
	GATE VALVE
	GAS OR AIR COCK

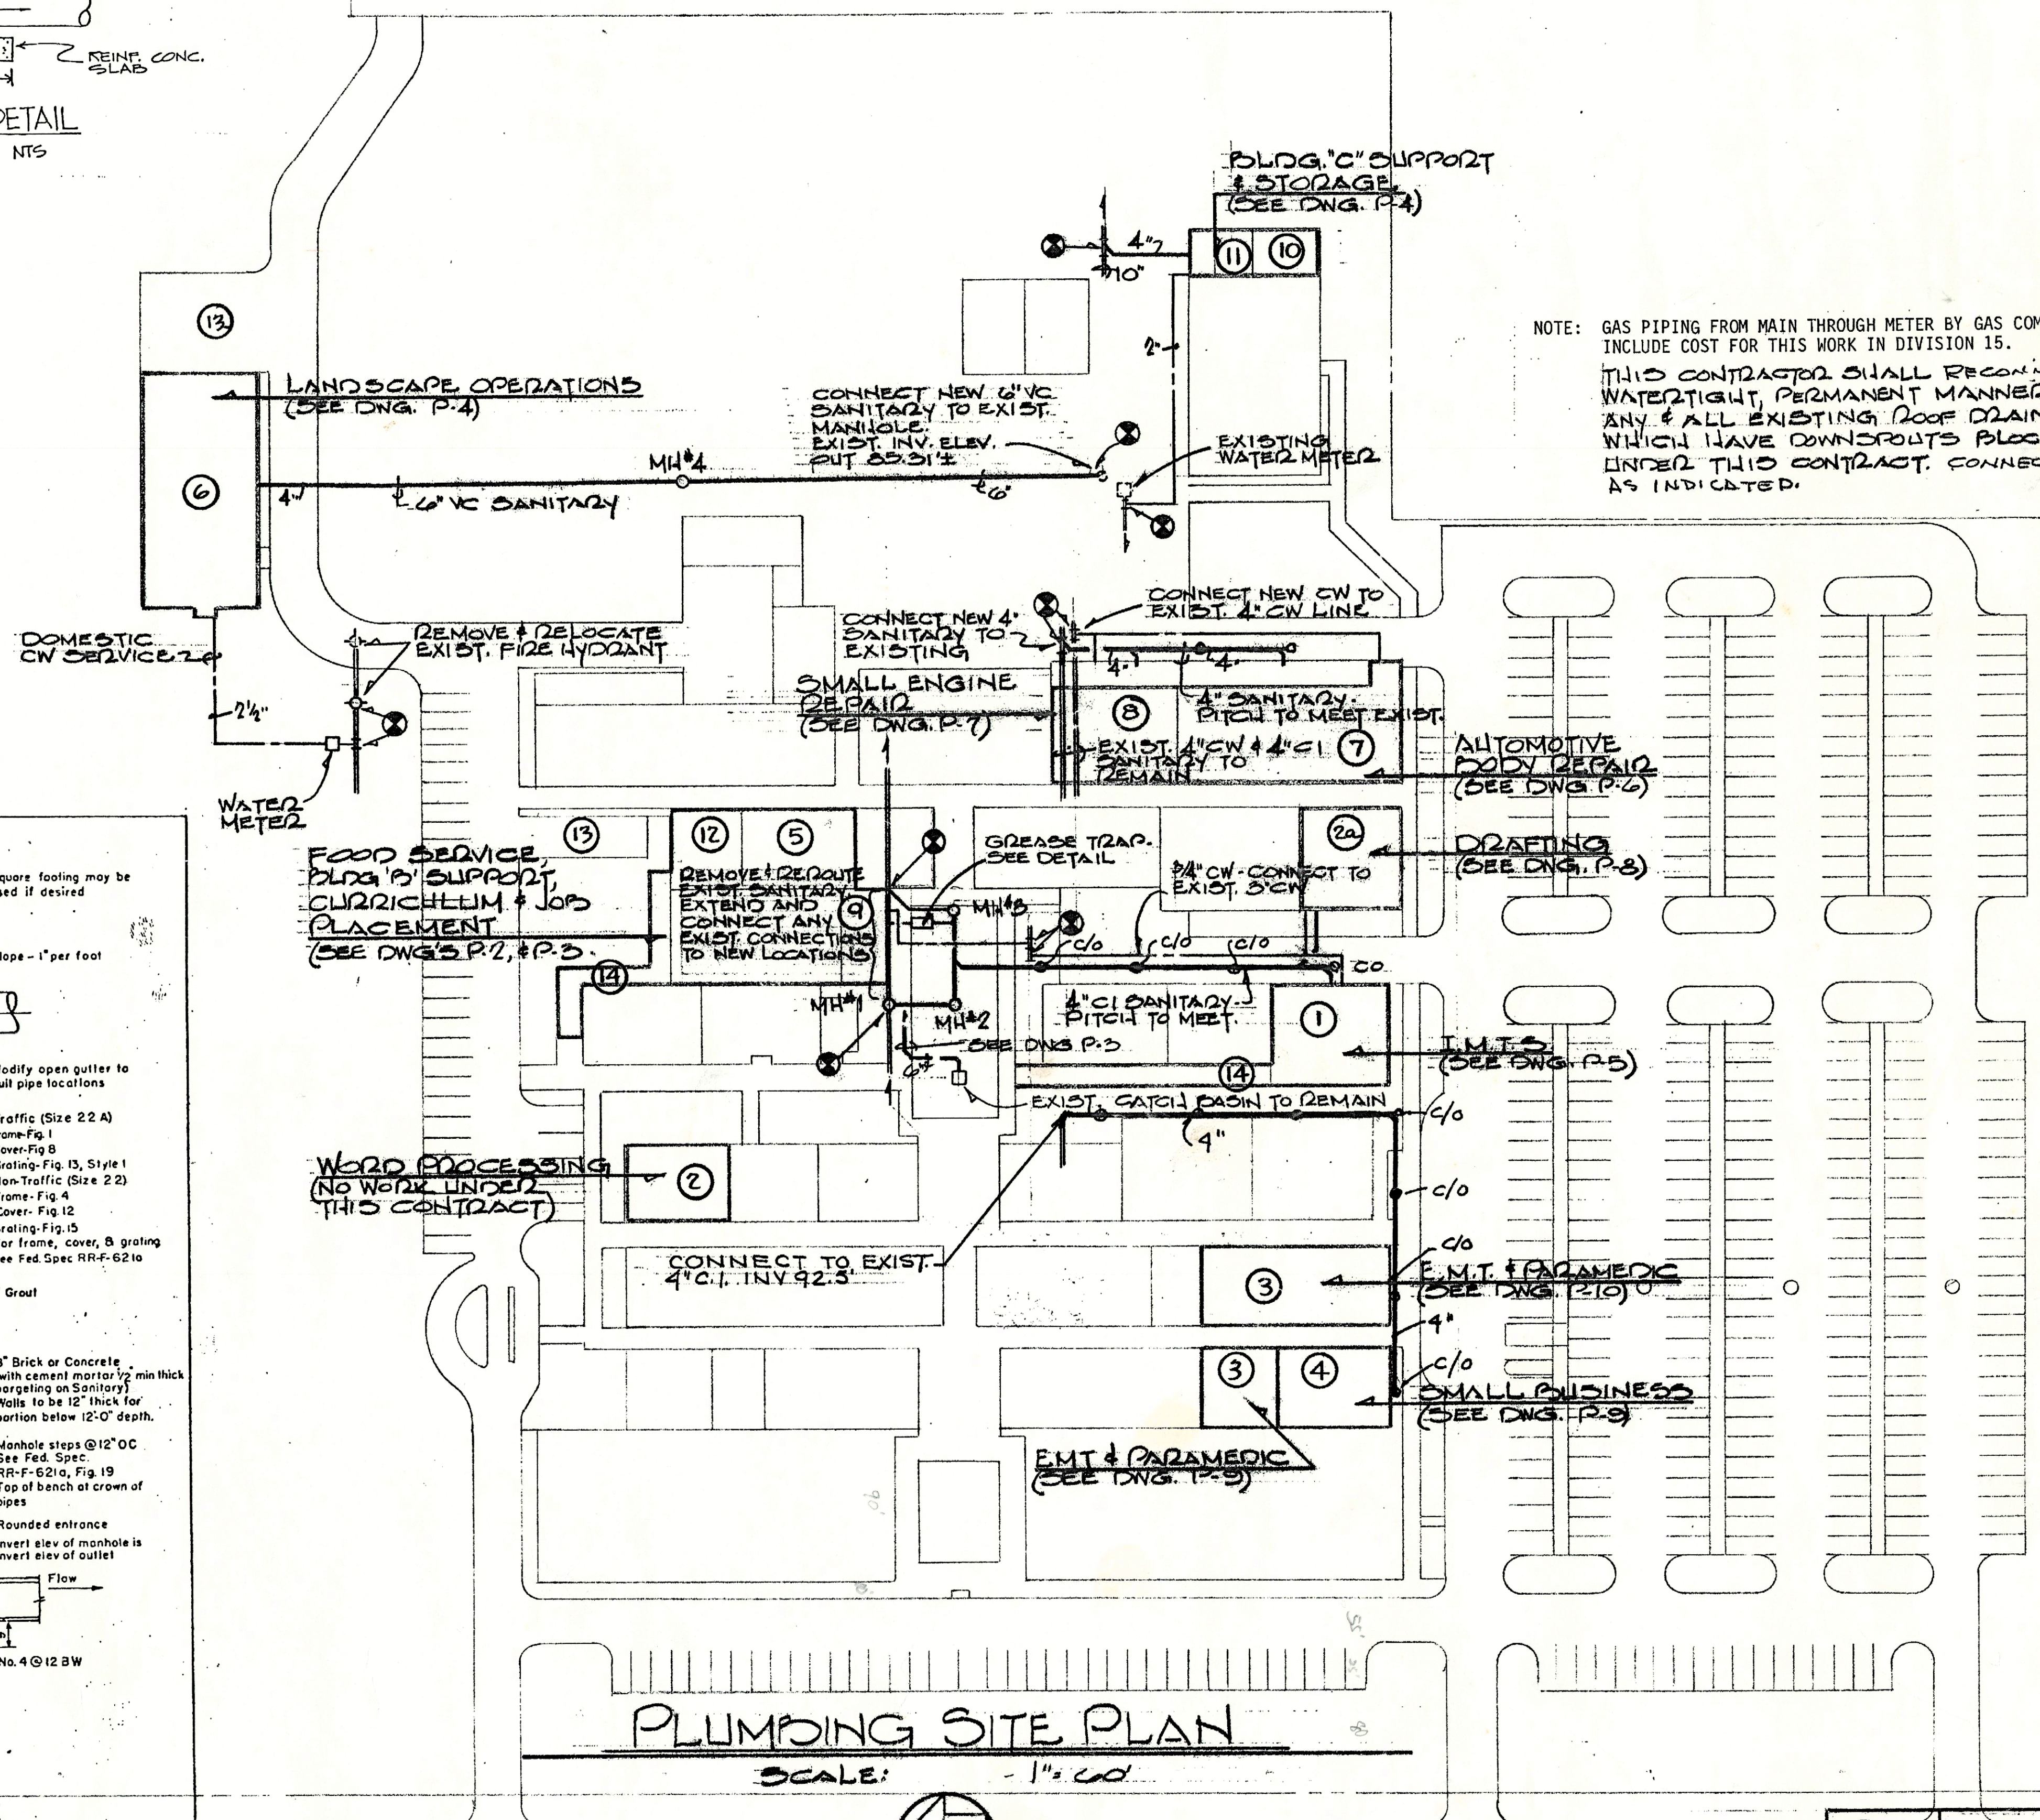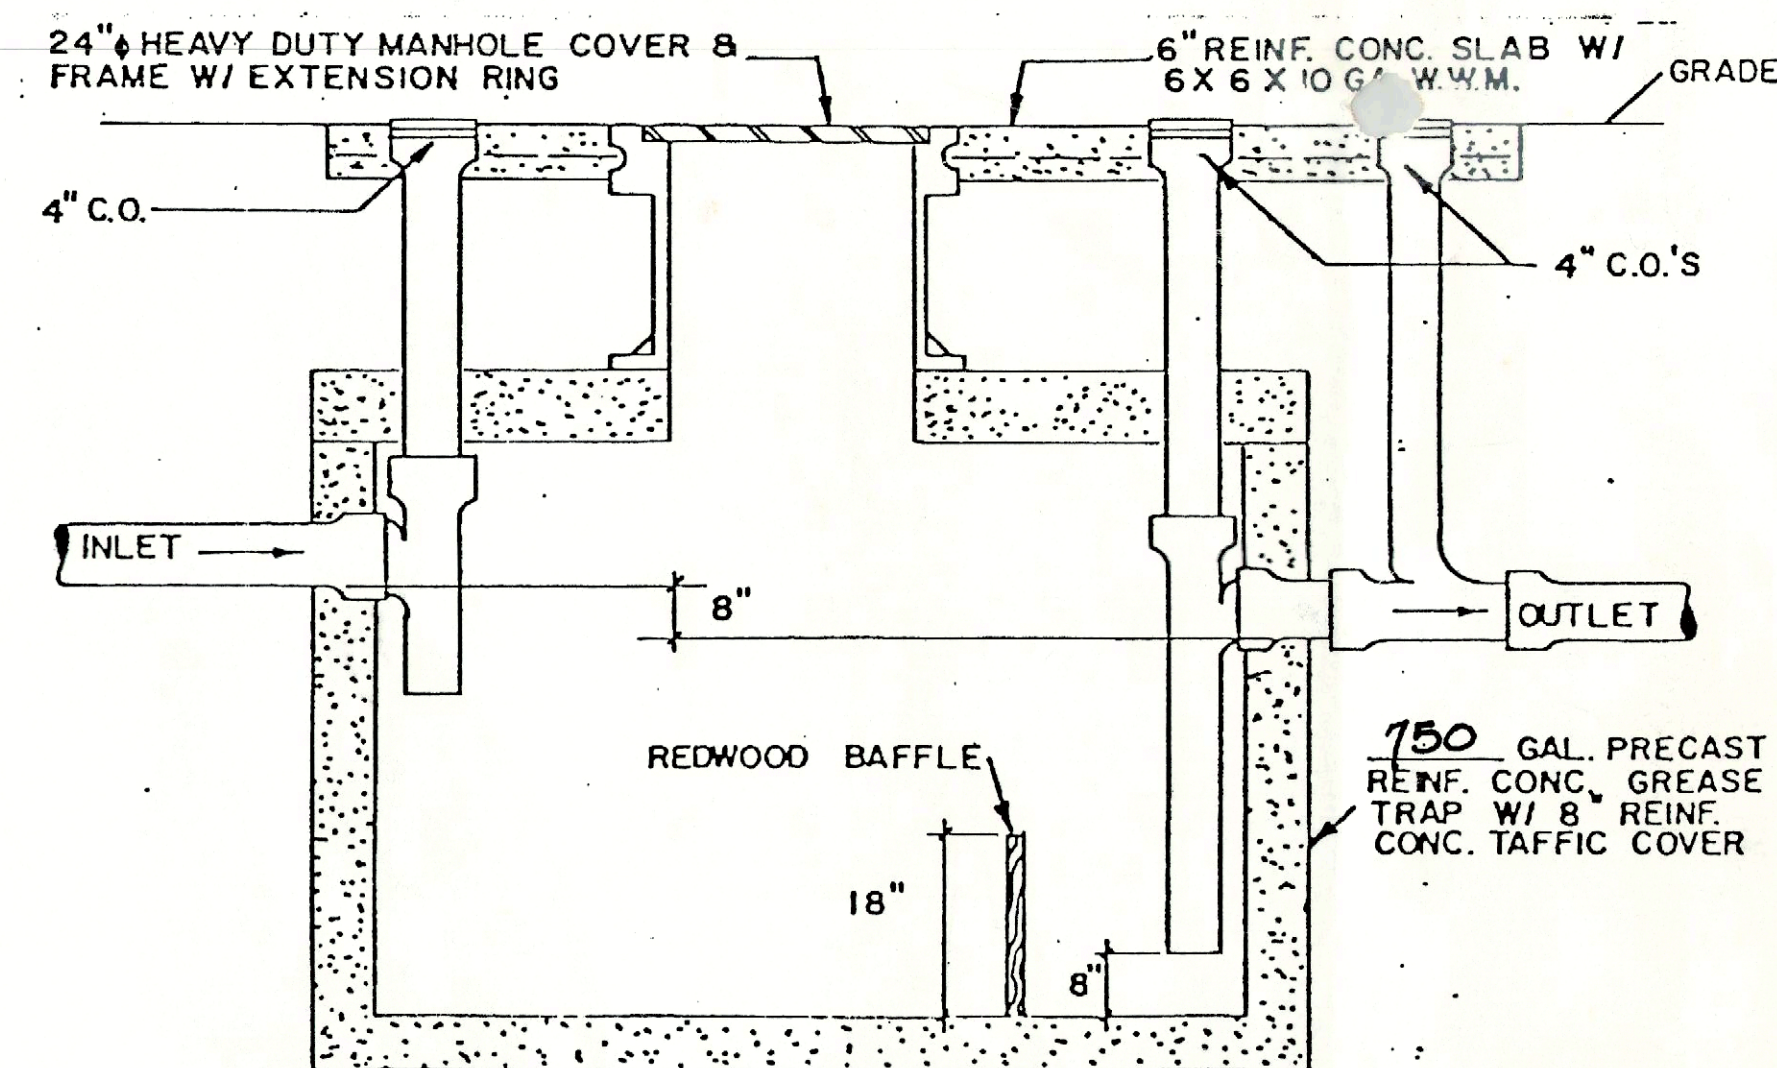

NOTE: GAS PIPING FROM MAIN THROUGH METER BY GAS COMPANY. INCLUDE COST FOR THIS WORK IN DIVISION 15.
THIS CONTRACTOR SHALL RECONSTRUCT (IN A WATER-TIGHT, PERMANENT MANNER) ANY & ALL EXISTING ROOF DRAINS, WHICH HAVE DOWNDRAUGHTS BLOCKED UNDER THIS CONTRACT. CONNECTION AS INDICATED.

Tilden Denson & Lobnitz, Inc.
Consulting Engineers
940 Highland Ave. Ph. 841-9050
ORLANDO, FLORIDA 32803




36
OF 91

Hopson & Cleland Architects, Inc.

SCHOOL BOARD OF LAKE COUNTY



VOCATIONAL TECHNICAL CENTER

Job No. 7711
SHEET

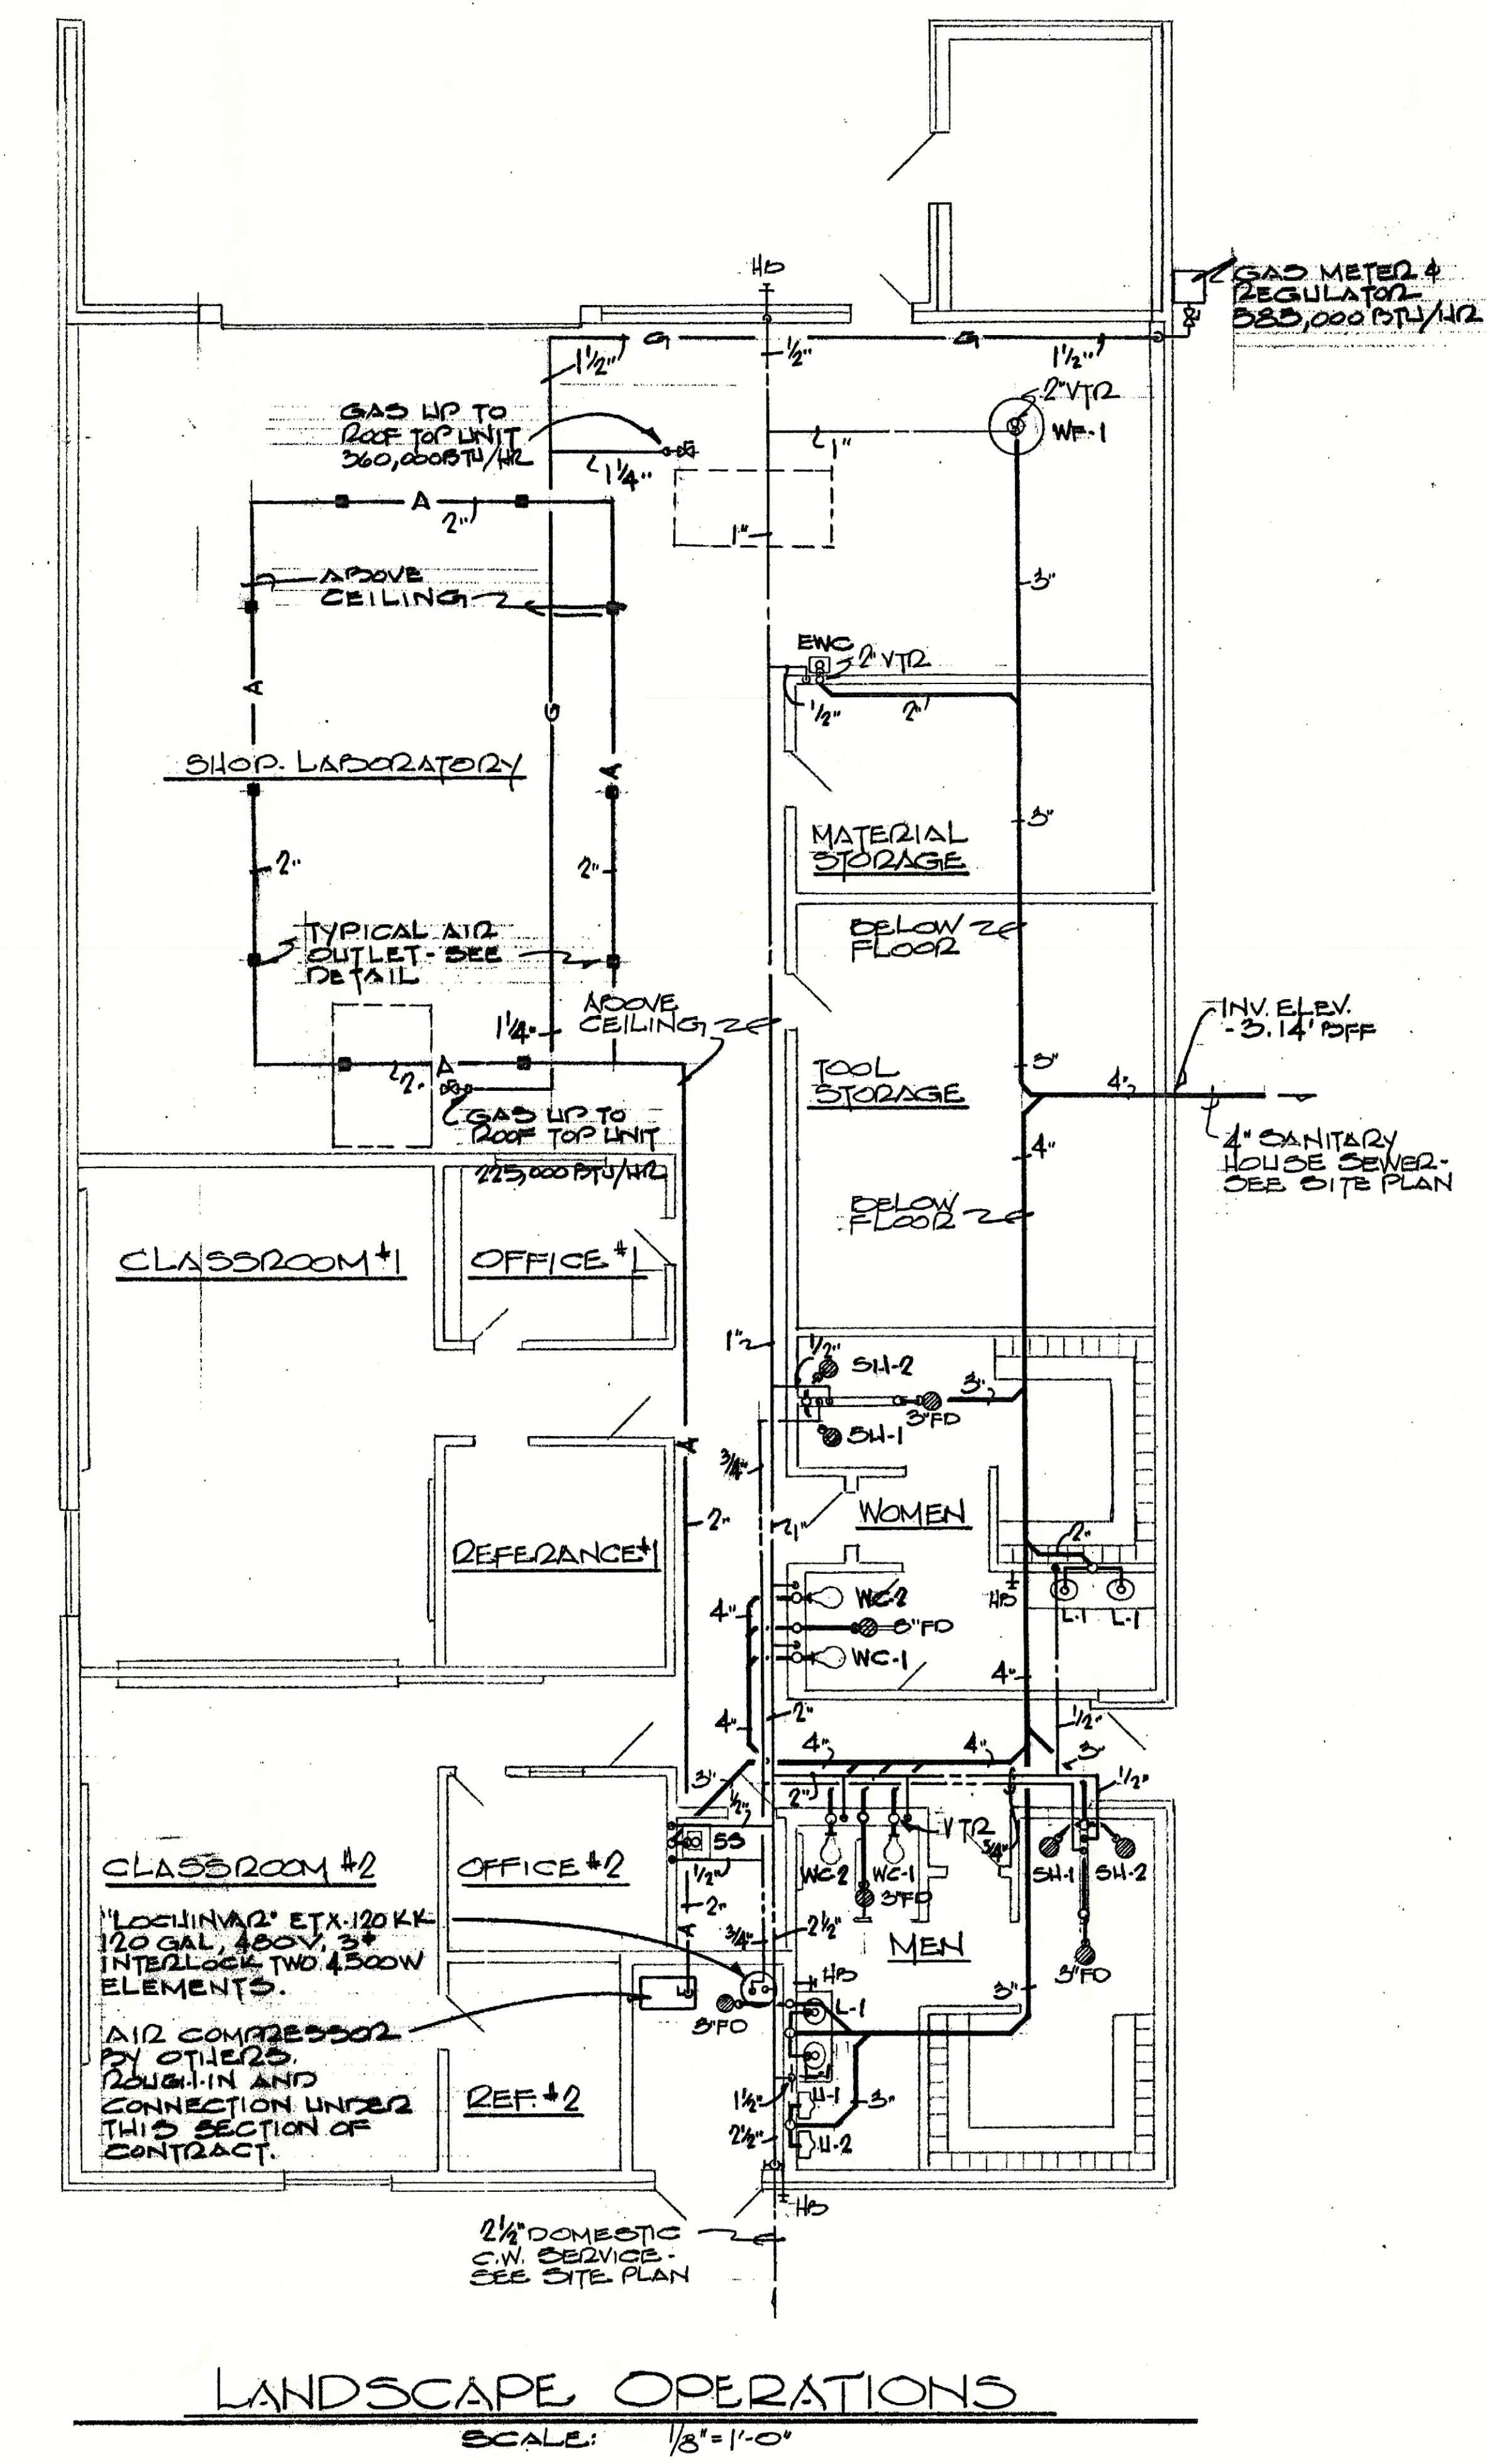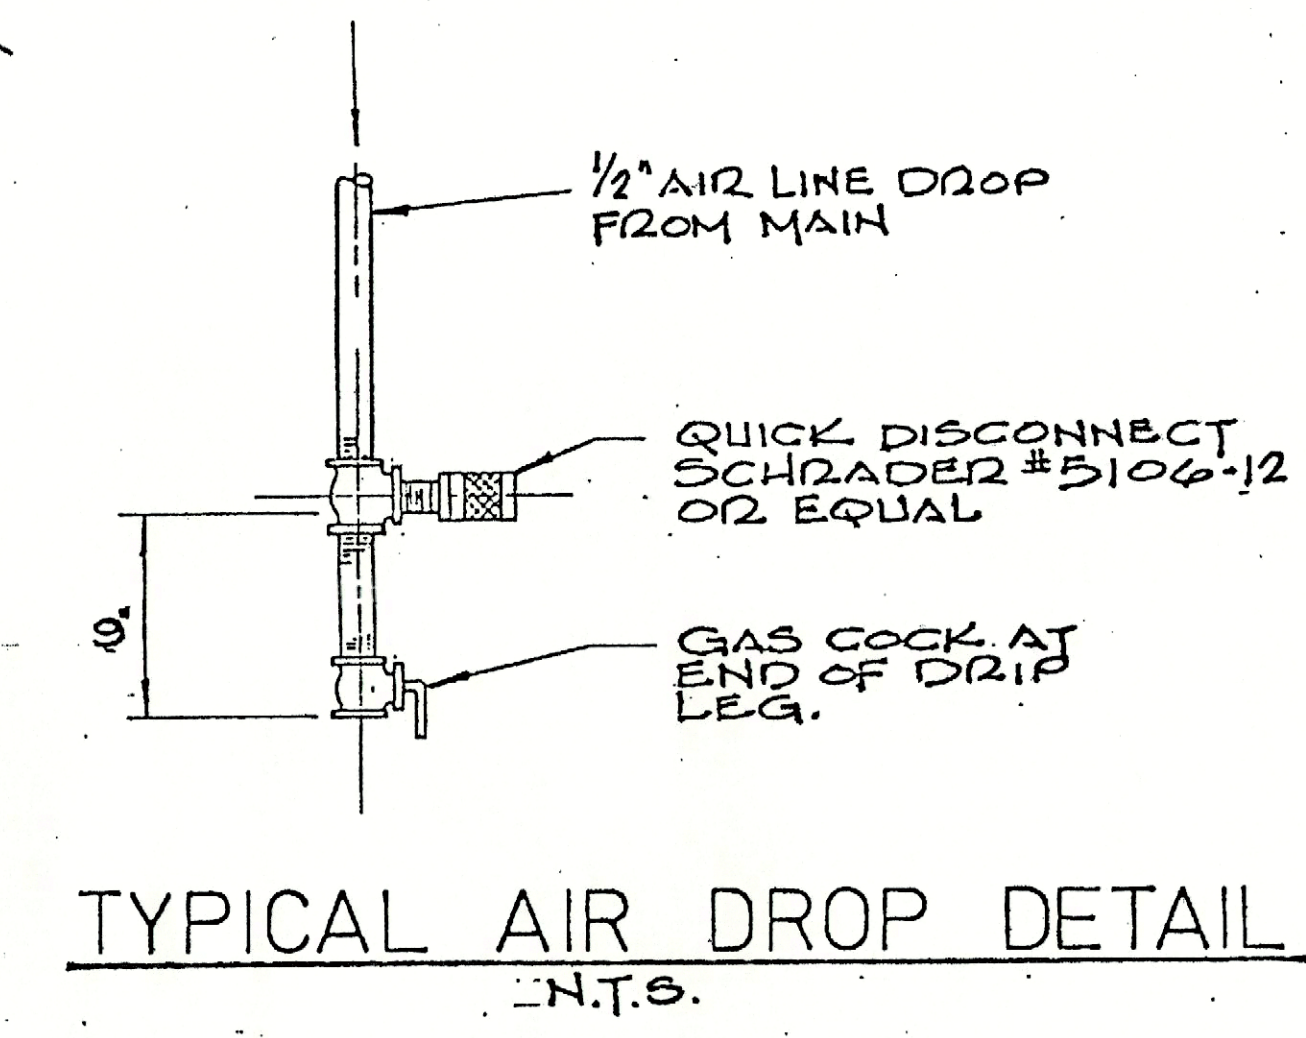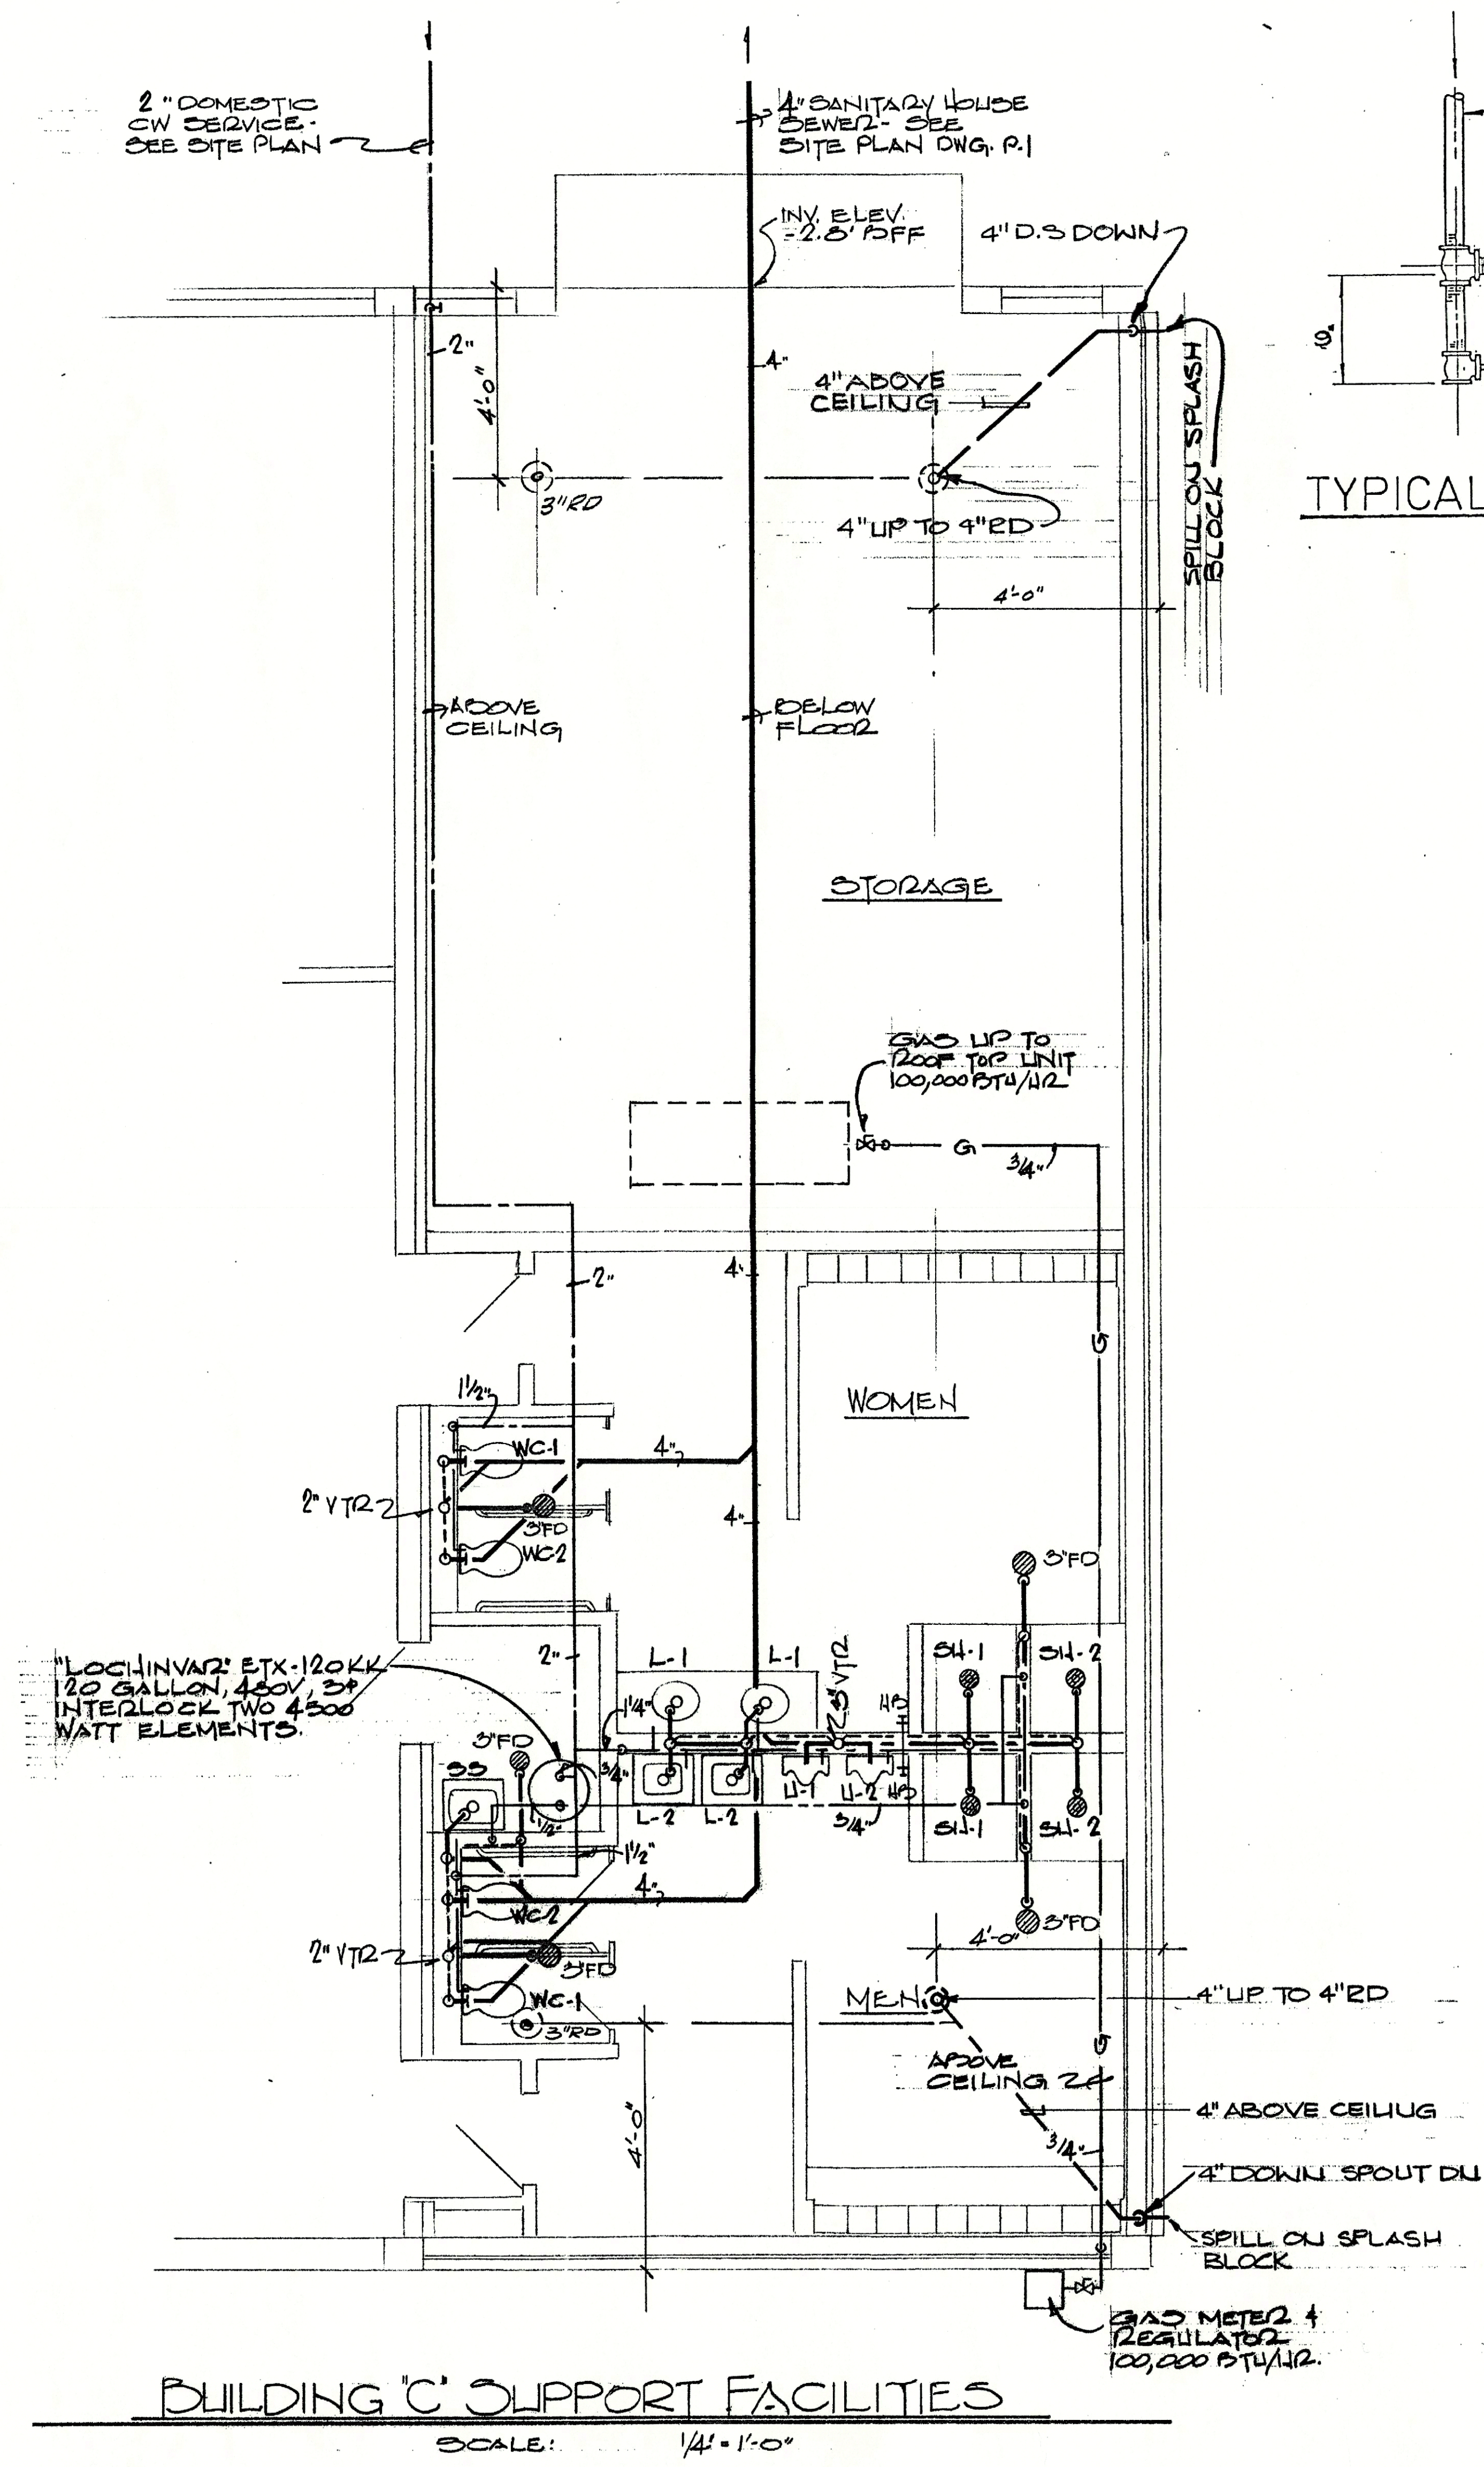

P-4
OF 10

Tilden Denson & Lobnitz, Inc.
Consulting Engineers
940 Highland Ave. Ph. 843-9050
ORLANDO, FLORIDA 32803

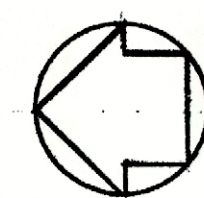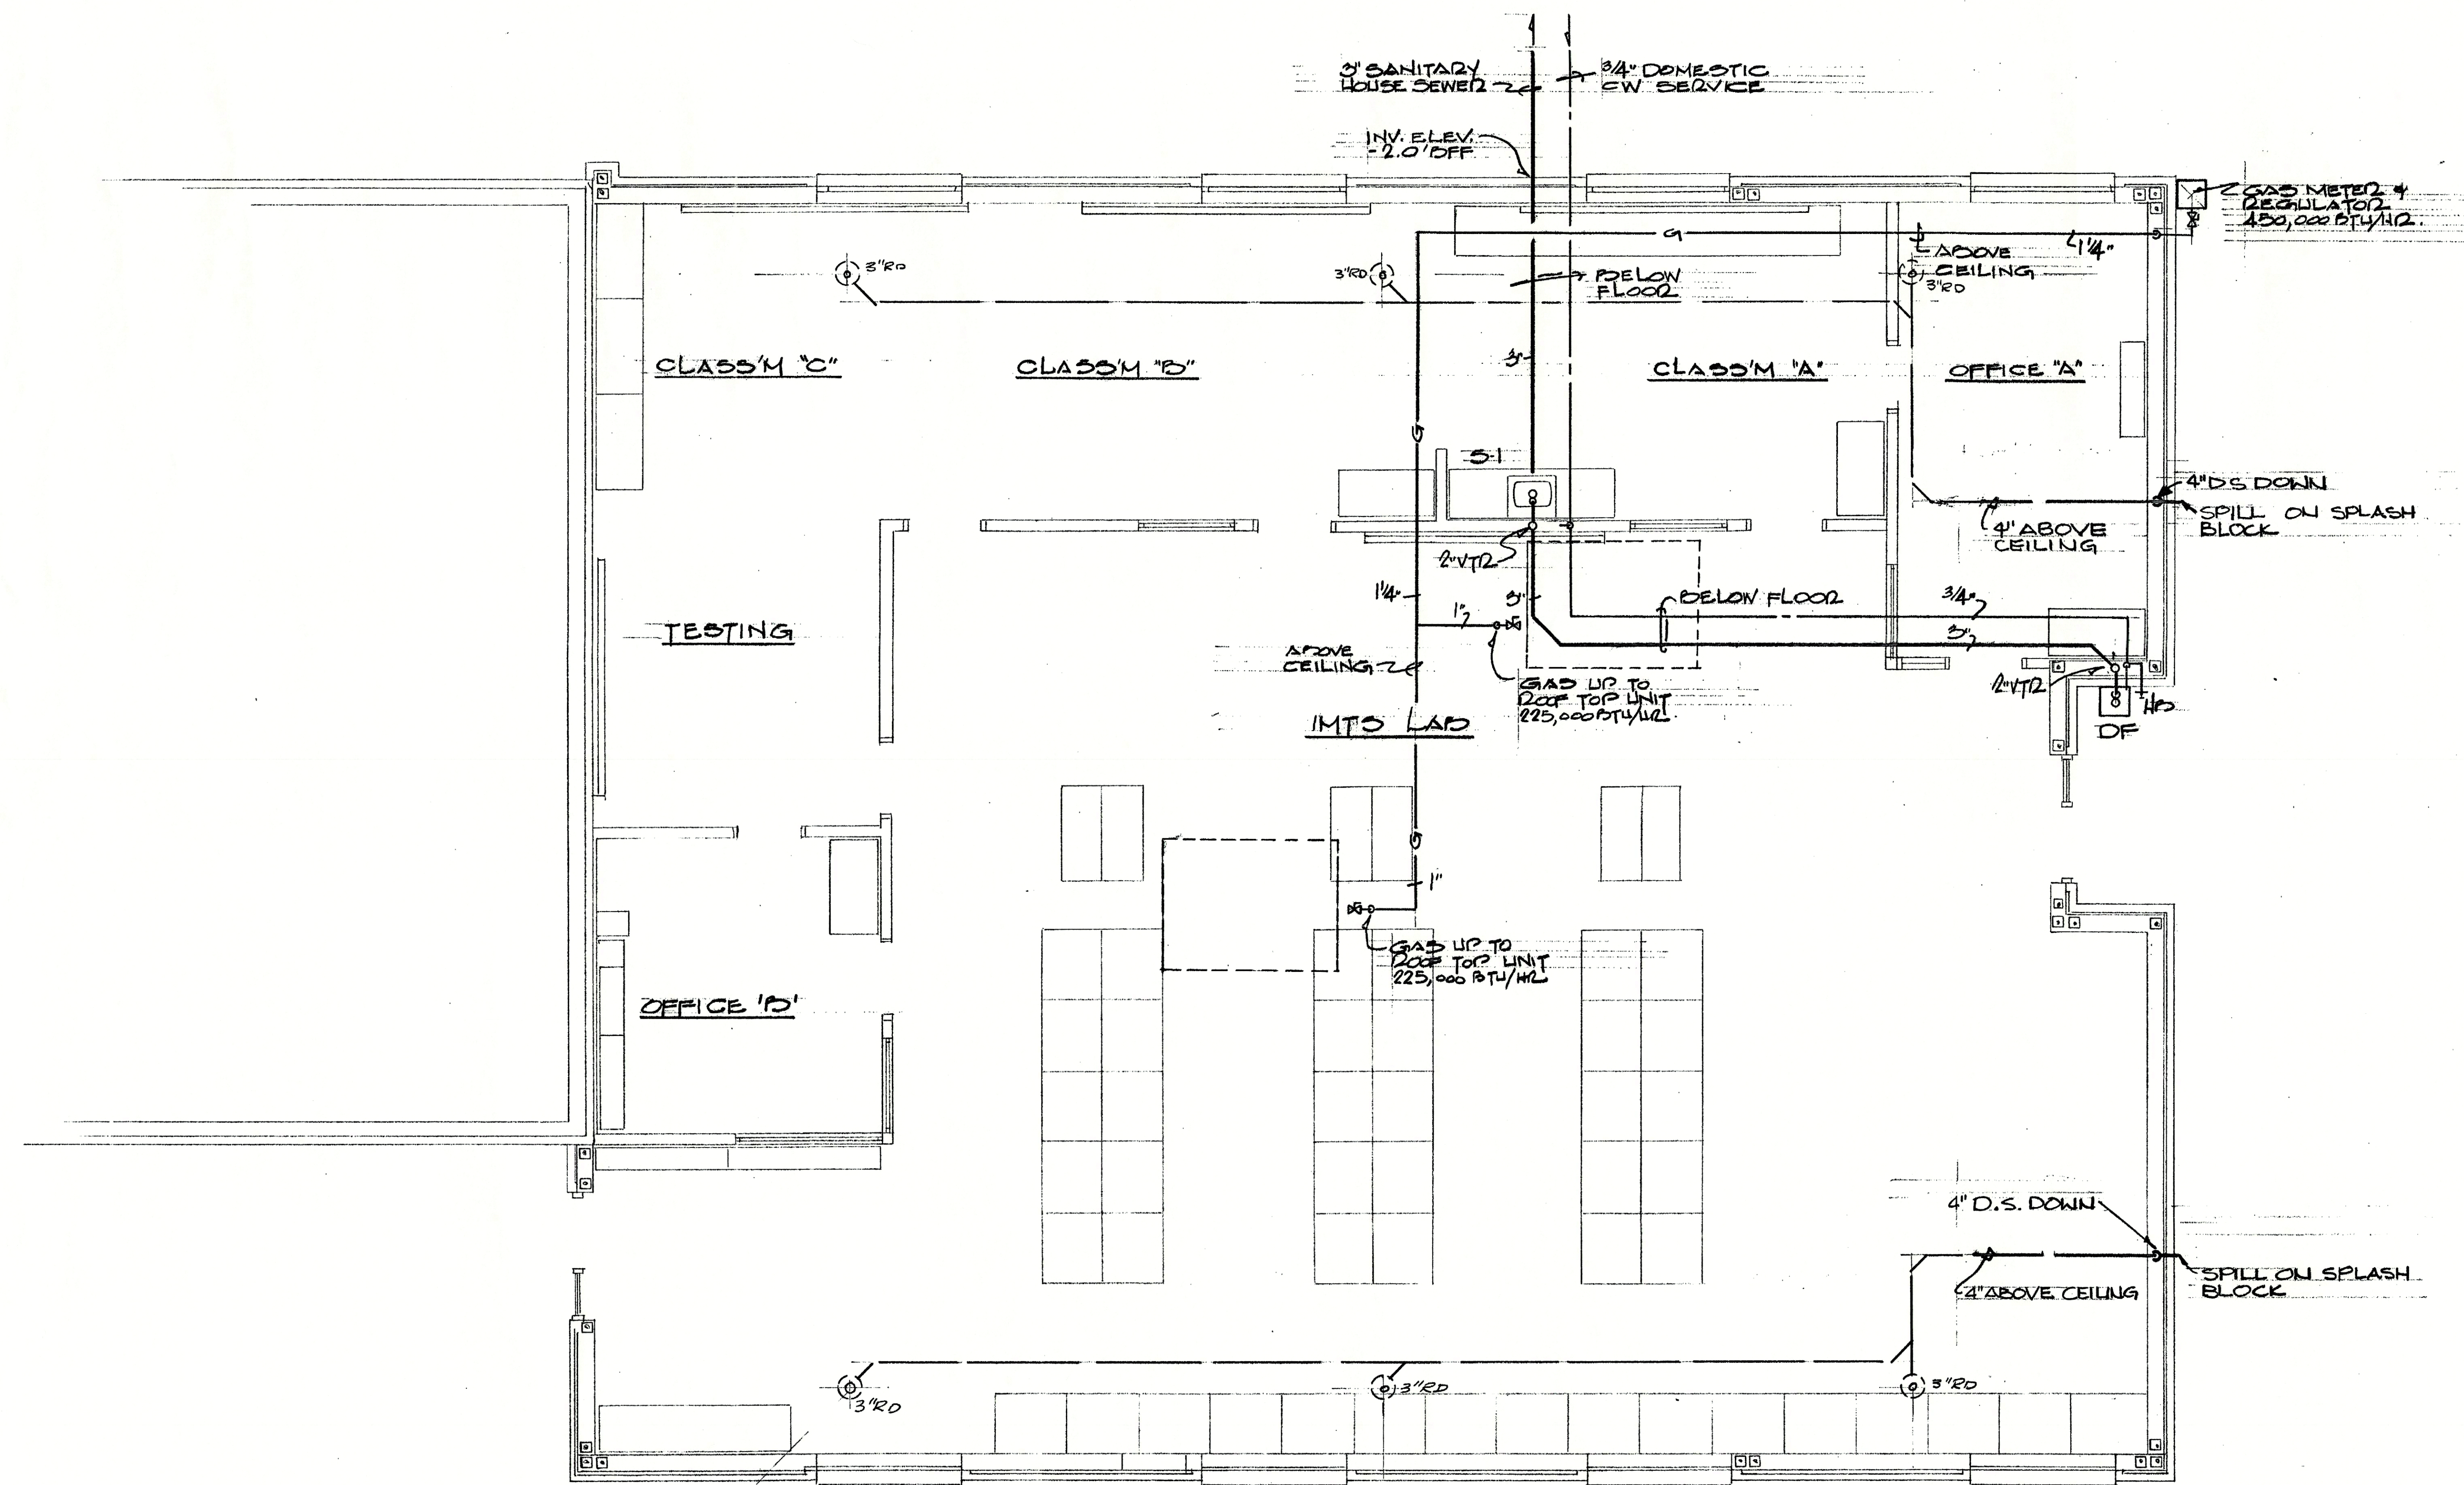

FLOOR PLAN

SCALE: 1/4" = 1'-0"


IMTS

R5
OF
10

Tilden Denson & Lobnitz, Inc.
Consulting Engineers
940 Highland Ave. Ph. 841-9090
ORLANDO, FLORIDA 32803

40

OF 91


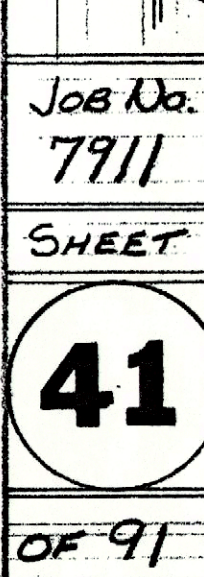


Job No.
7911

SHEET

41

OF 91

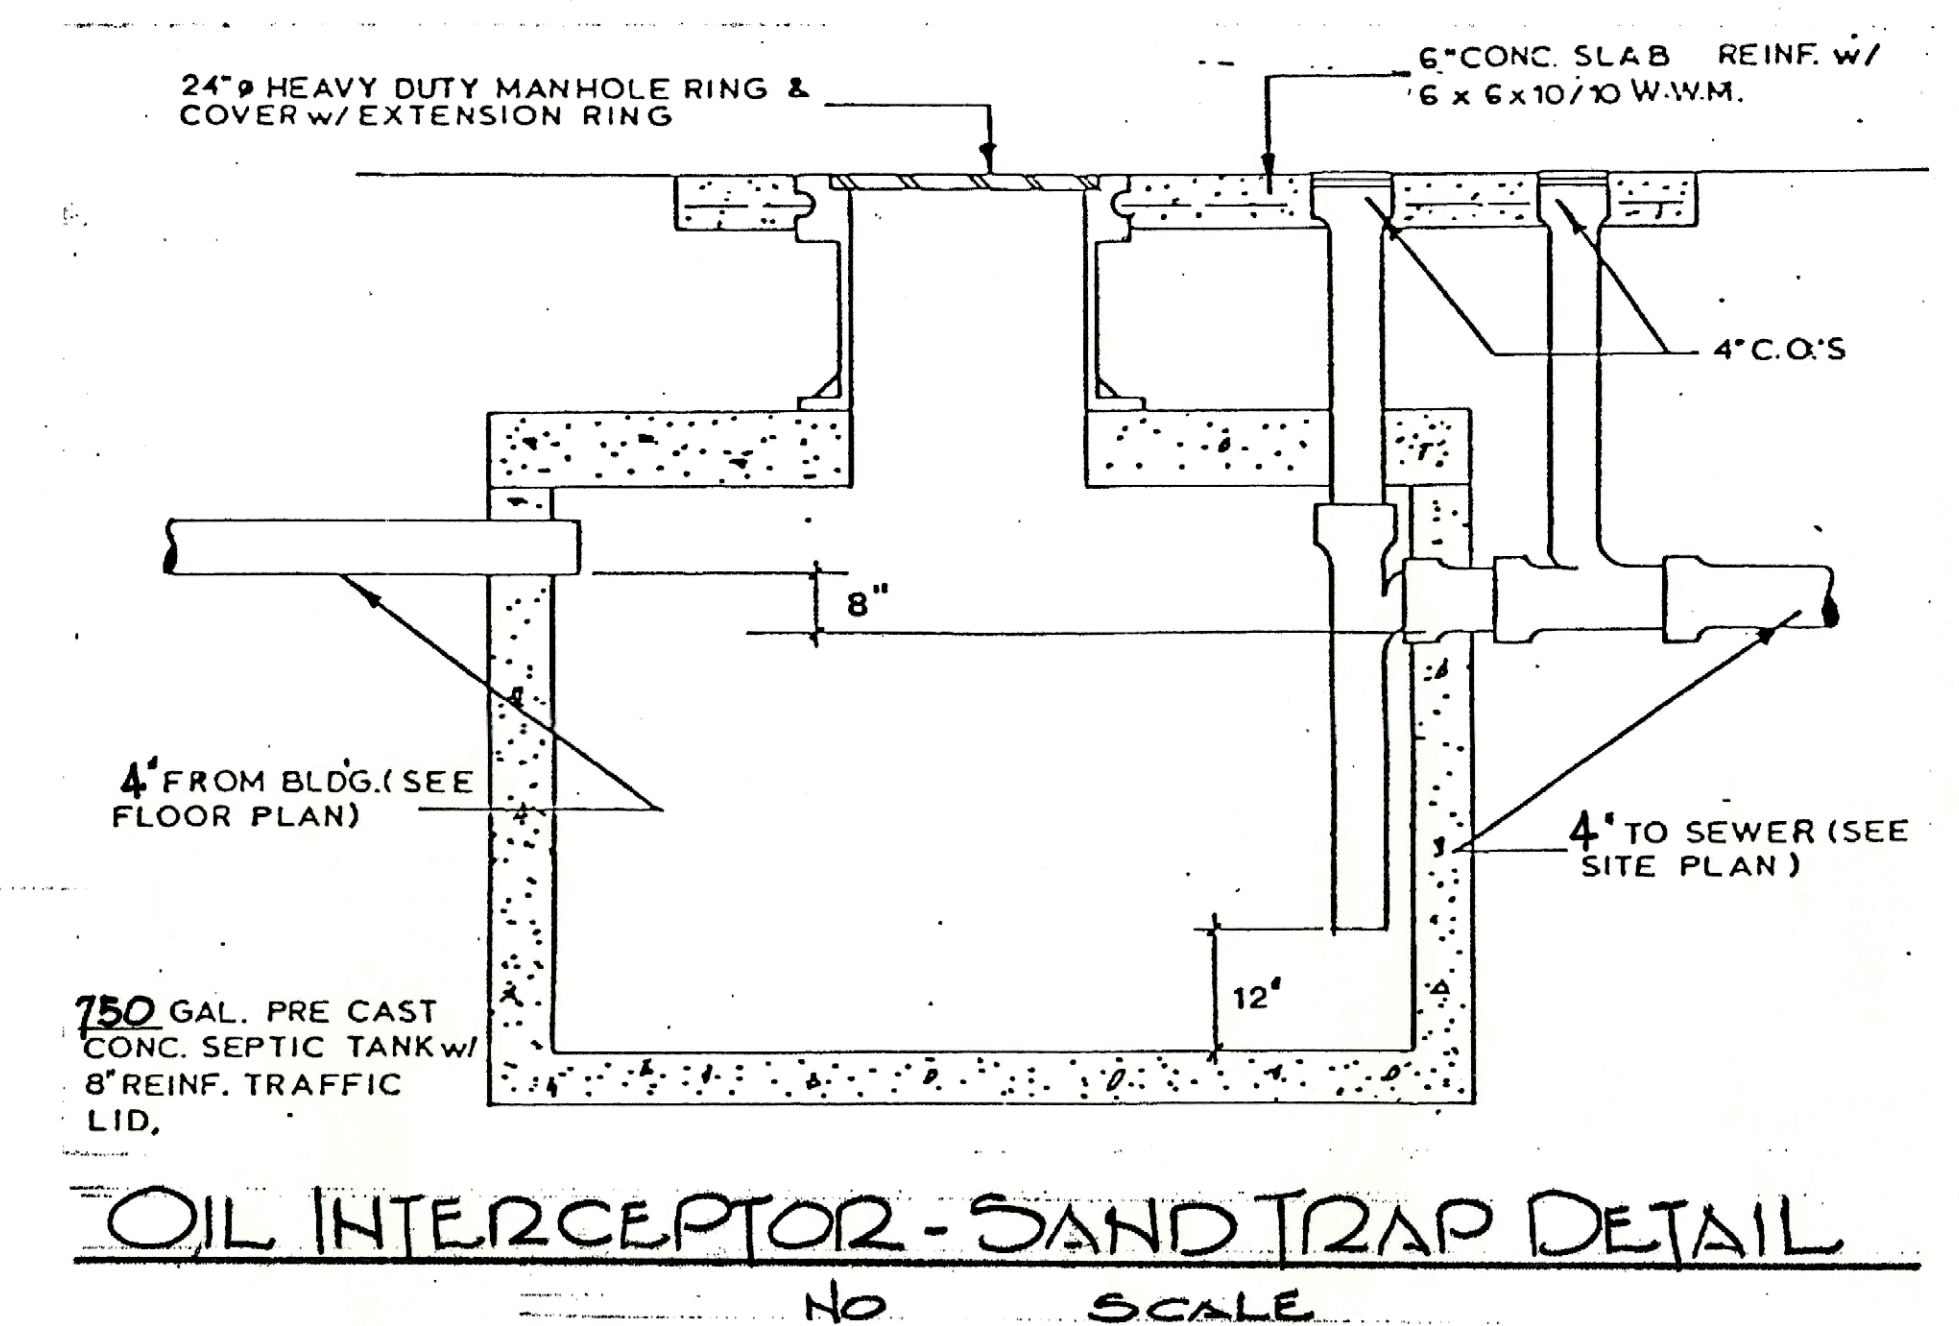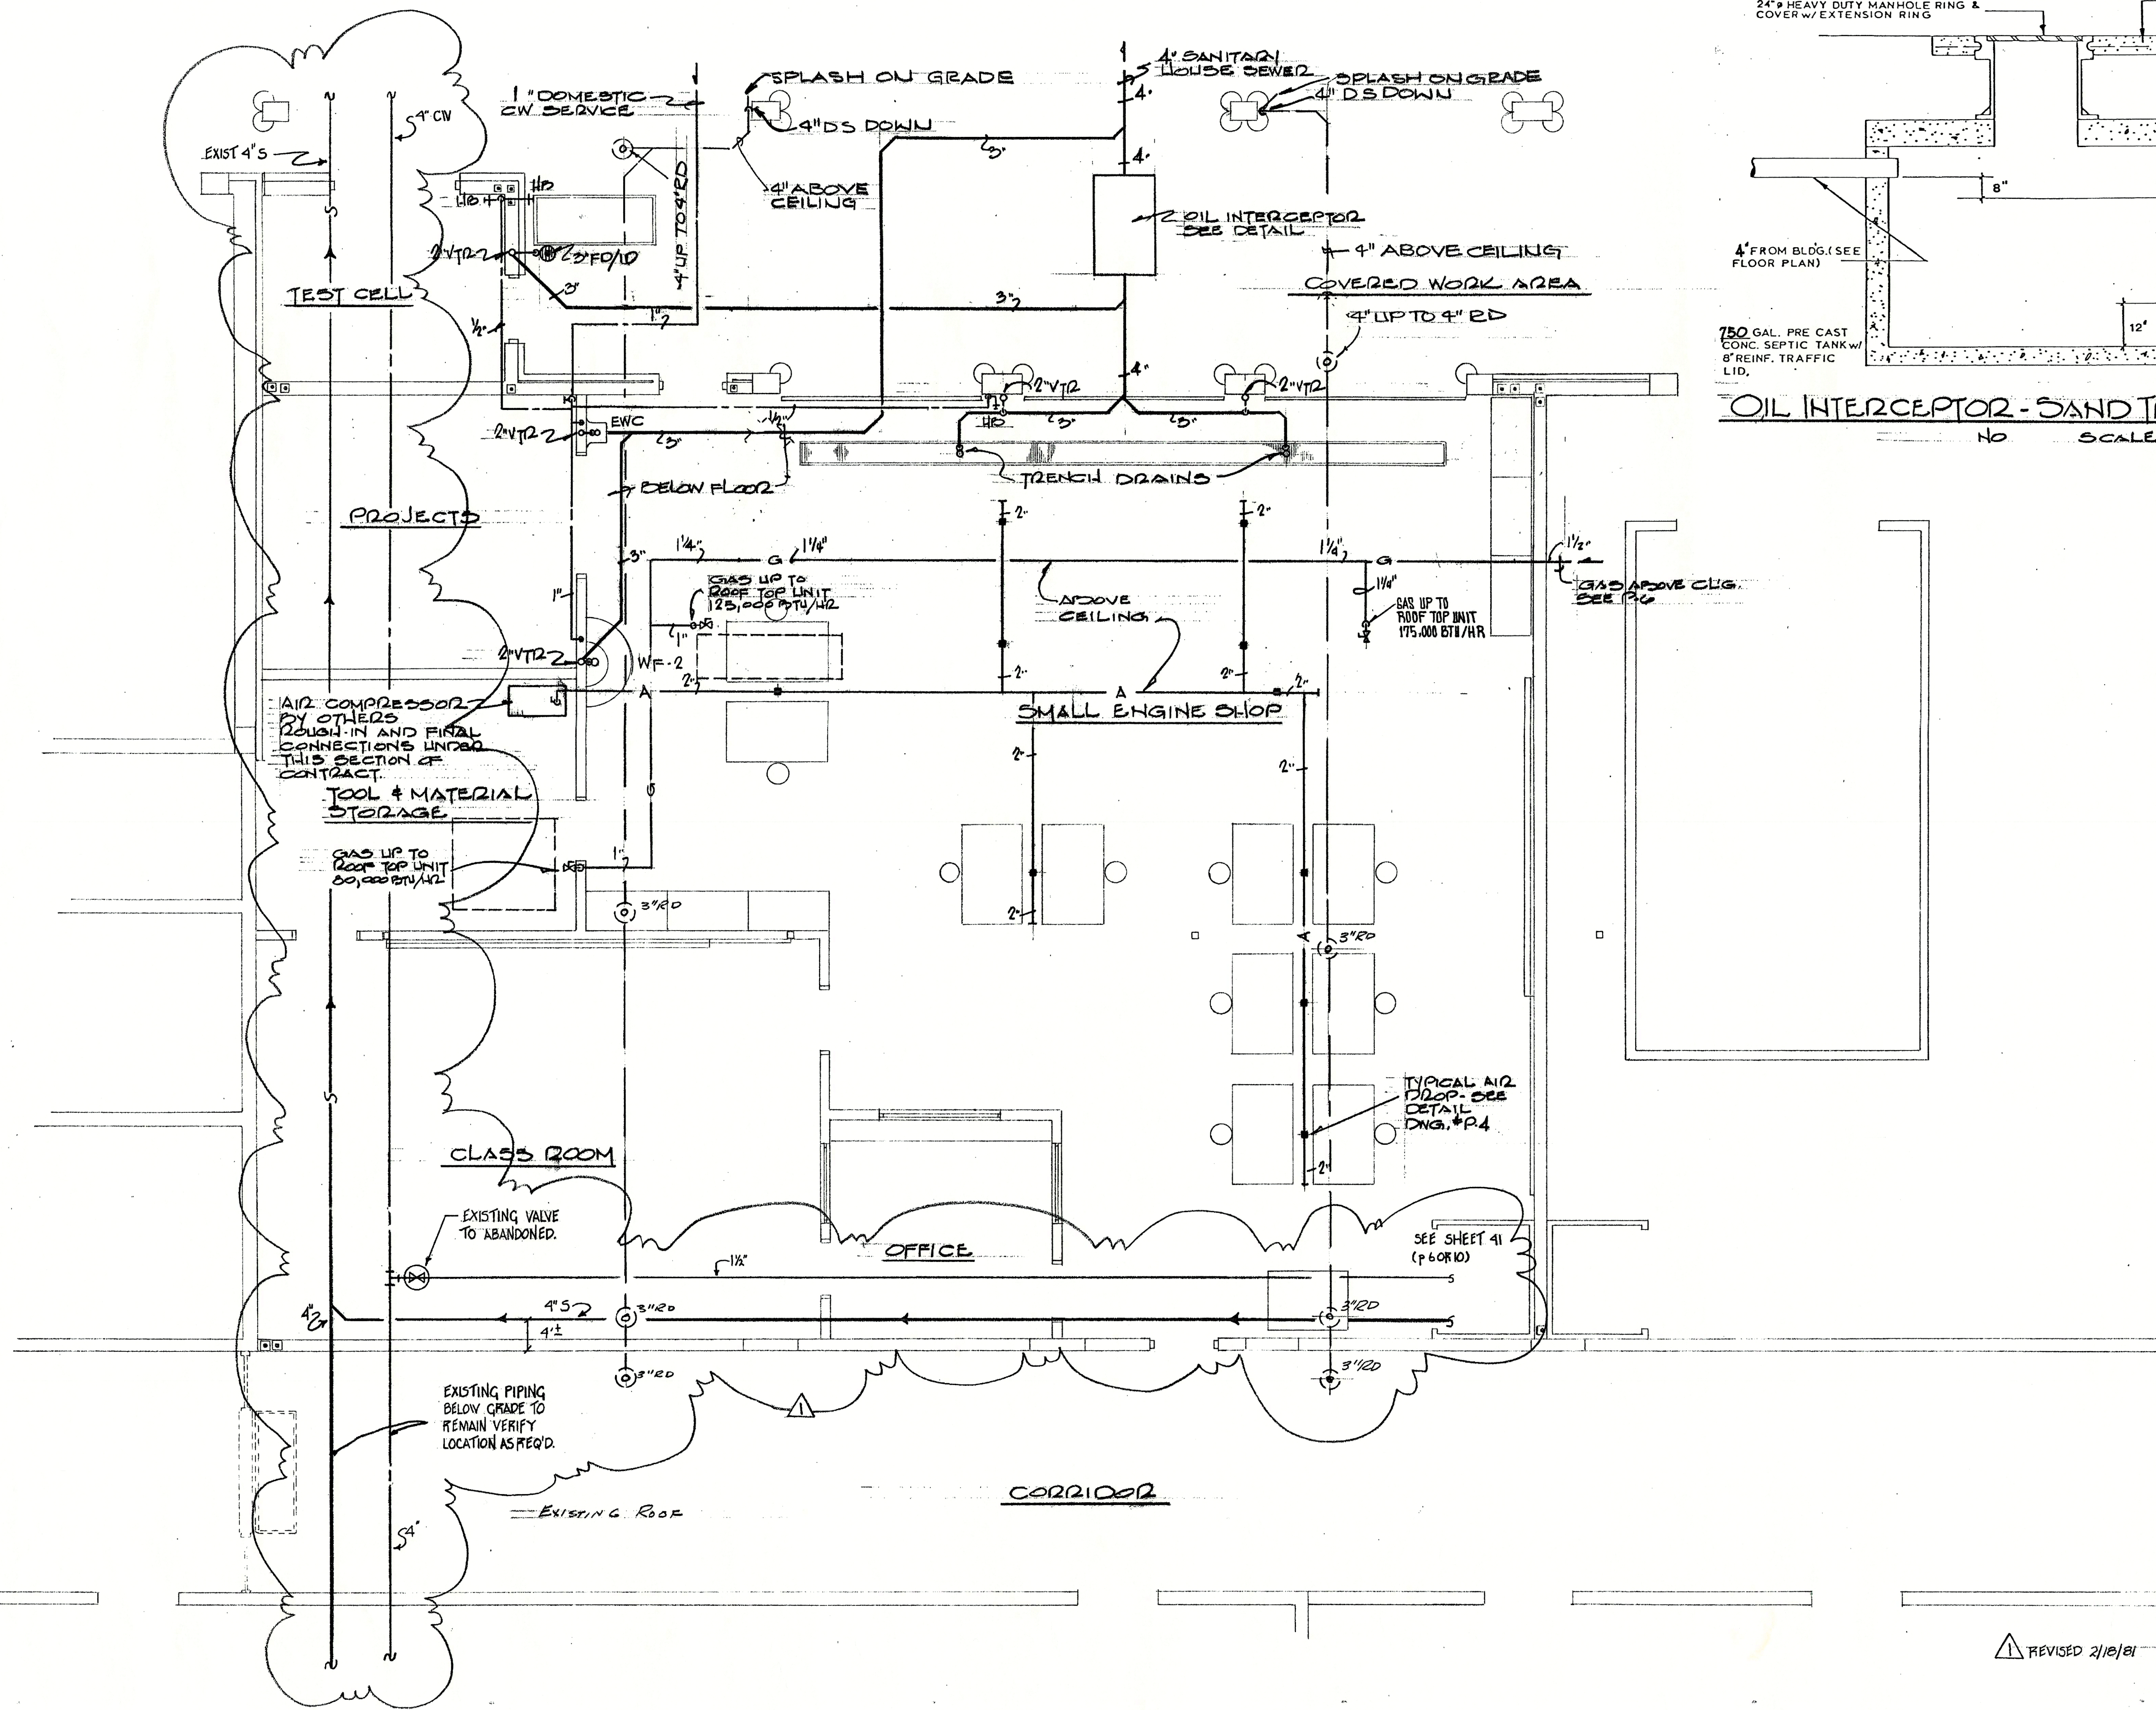


REVISD 2/18/81

SMALL ENGINE REPAIR


P.7
18

Tilden Denson & Lobnitz, Inc.
Consulting Engineers
940 Highland Ave. Ph. 841-9050
ORLANDO, FLORIDA 32803

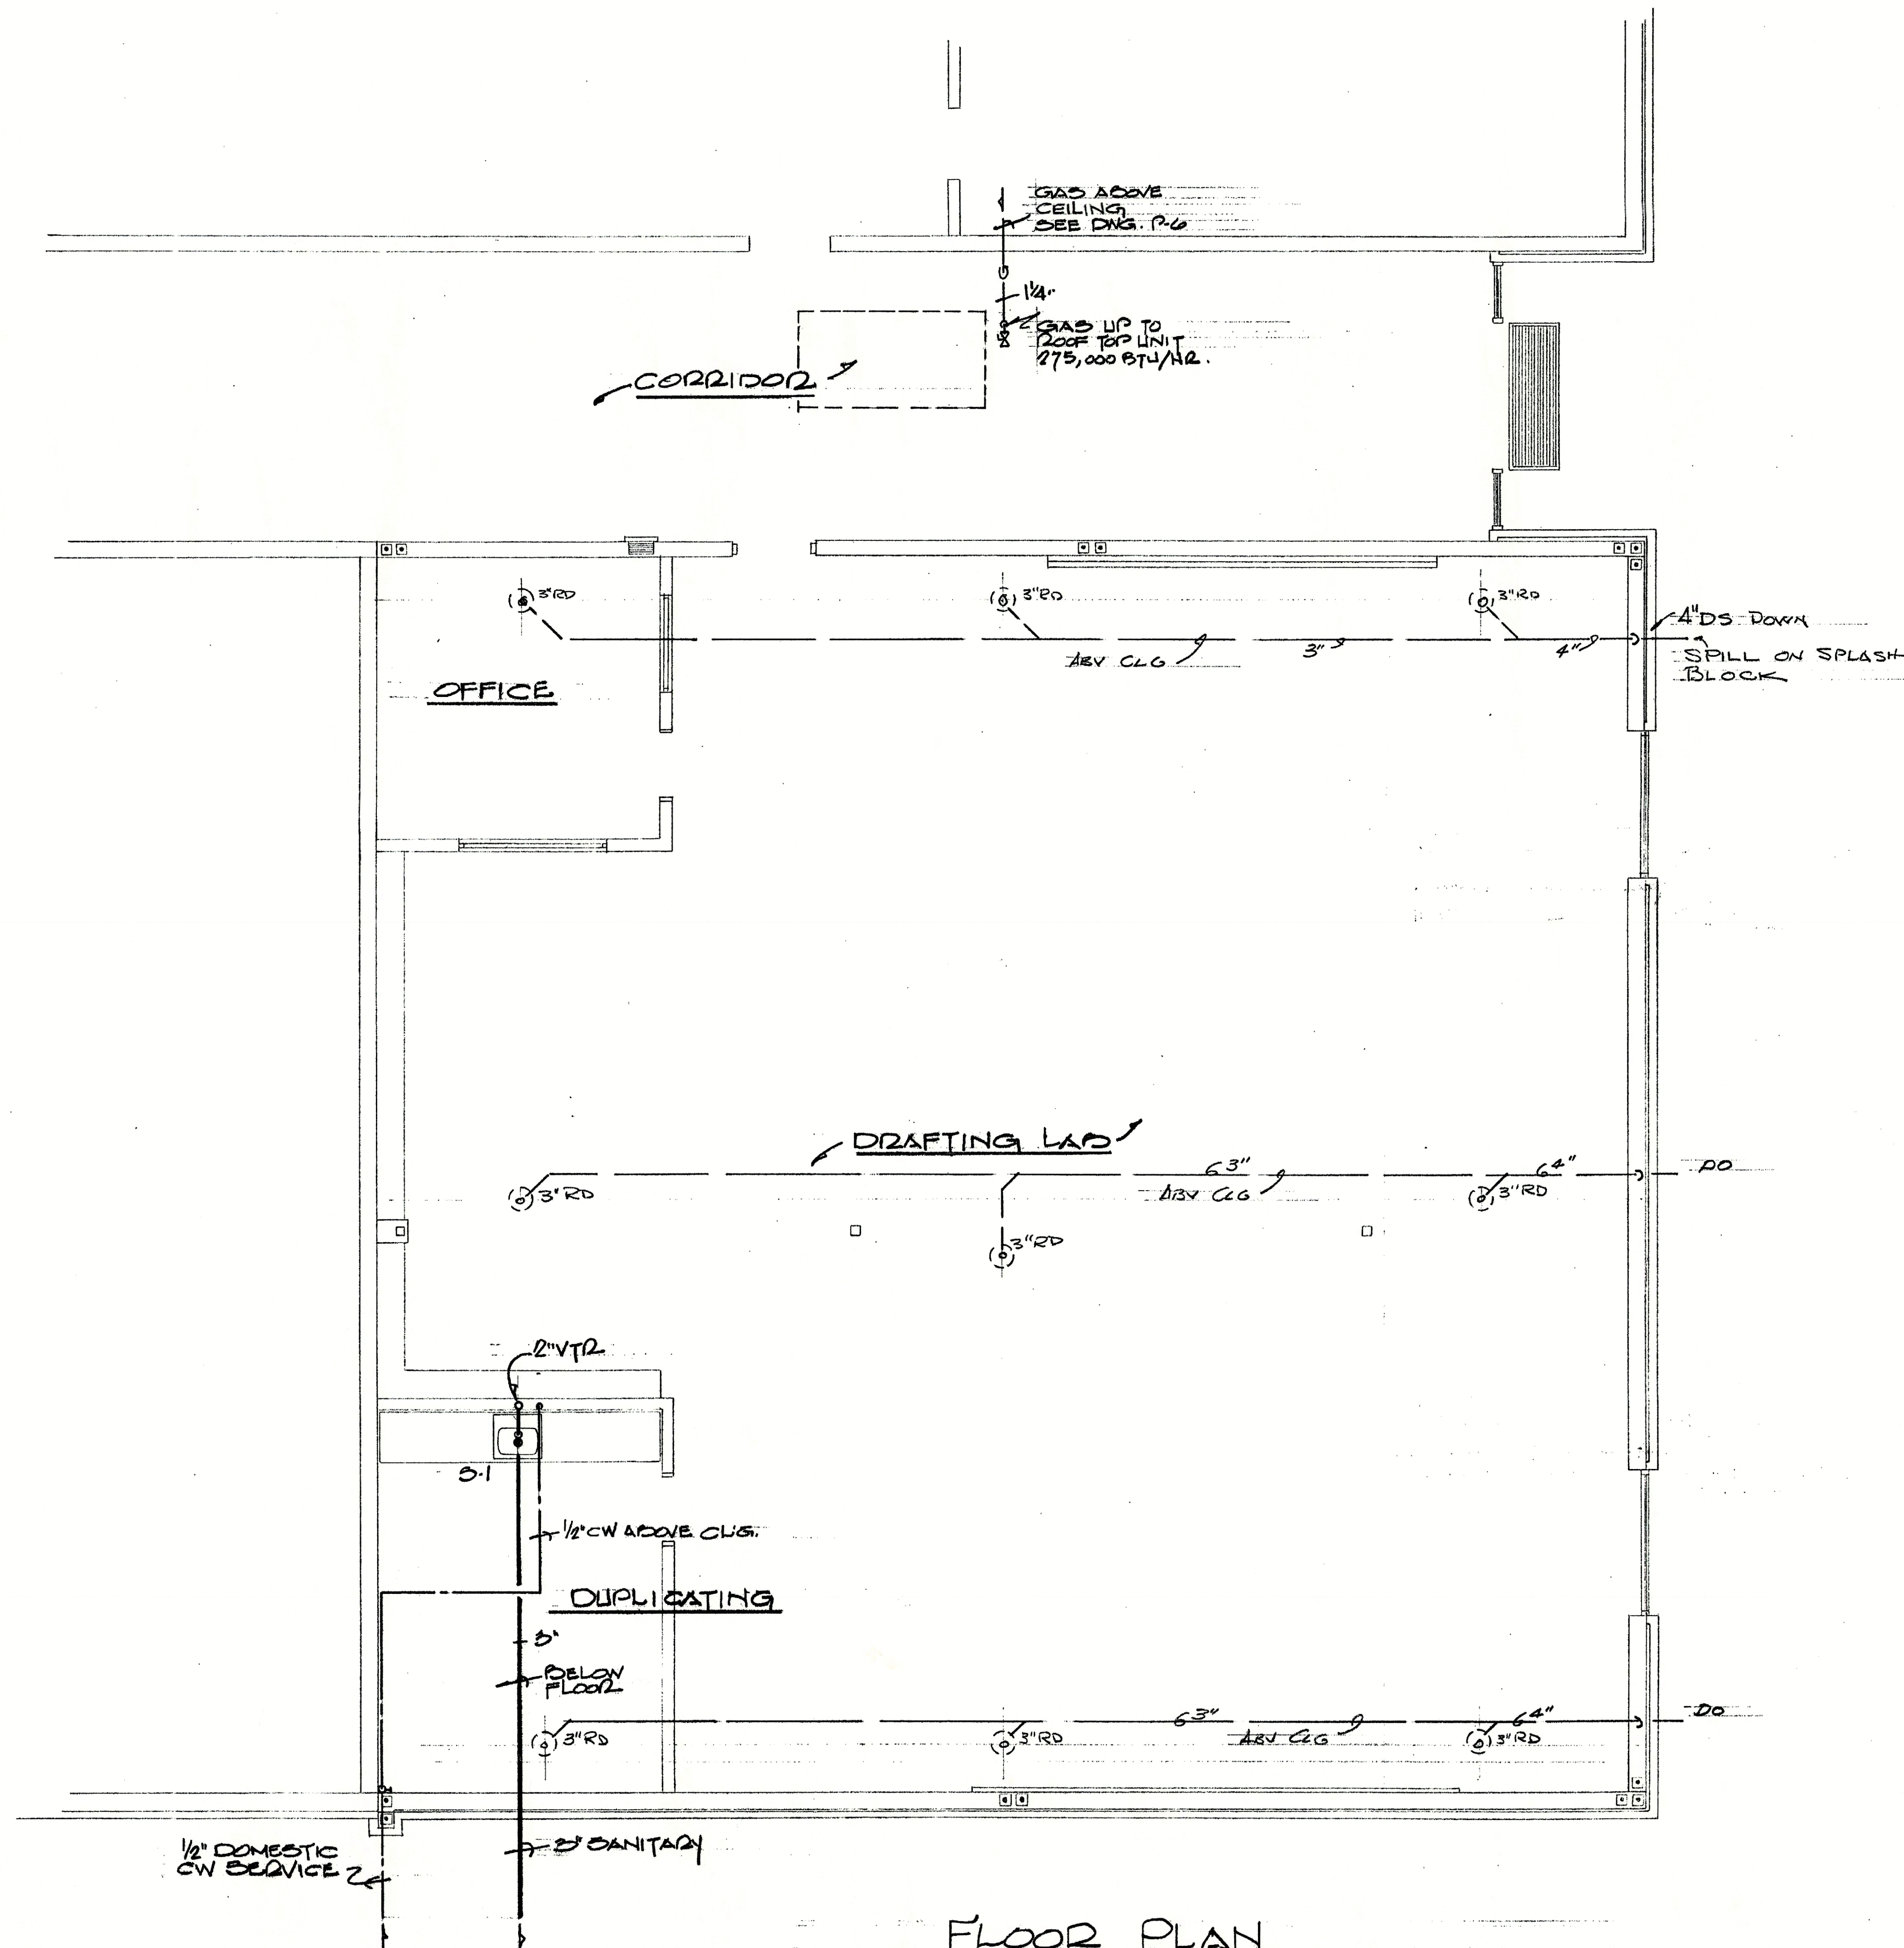

FLOOR PLAN

SCALE: 1/4" = 1'-0"

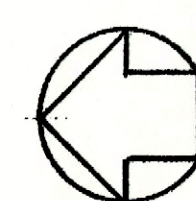

DRAFTING LAB

PB
OF
10

Tilden Denson & Lobnitz, Inc.
Consulting Engineers
940 Highland Ave. Ph. 841-9050
ORLANDO, FLORIDA 32803

Job No.
7911

SHEET

43

OF 91

Hopson & Cleland Architects Inc.

SCHOOL BOARD OF LAKE COUNTY

VOCATIONAL TECHNICAL CENTER
LUSTIS, FLORIDA

78-26-4

